
 
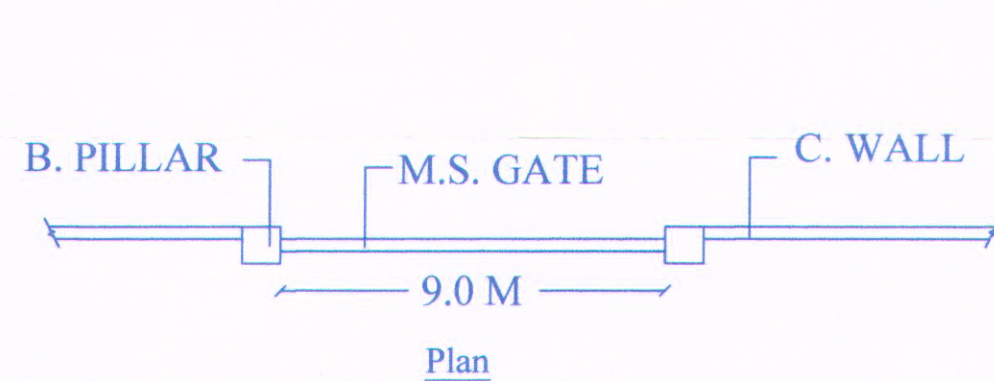

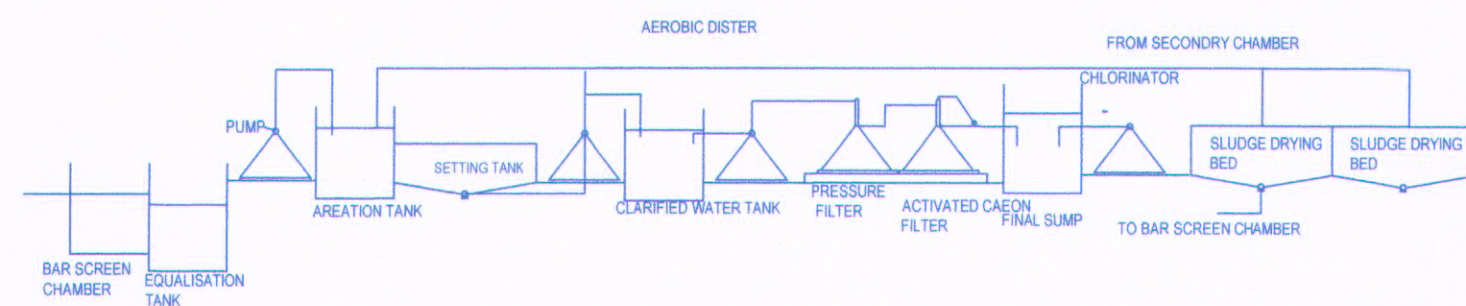
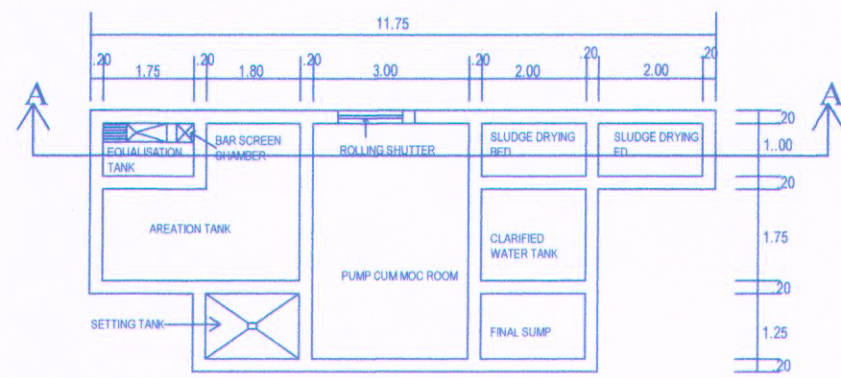
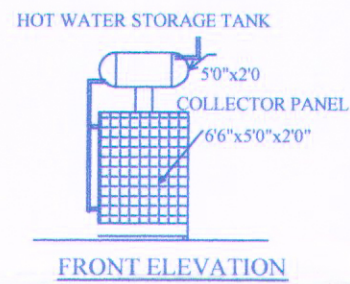
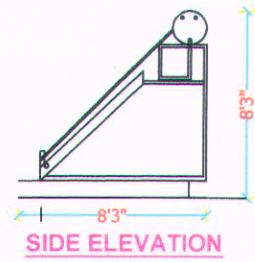
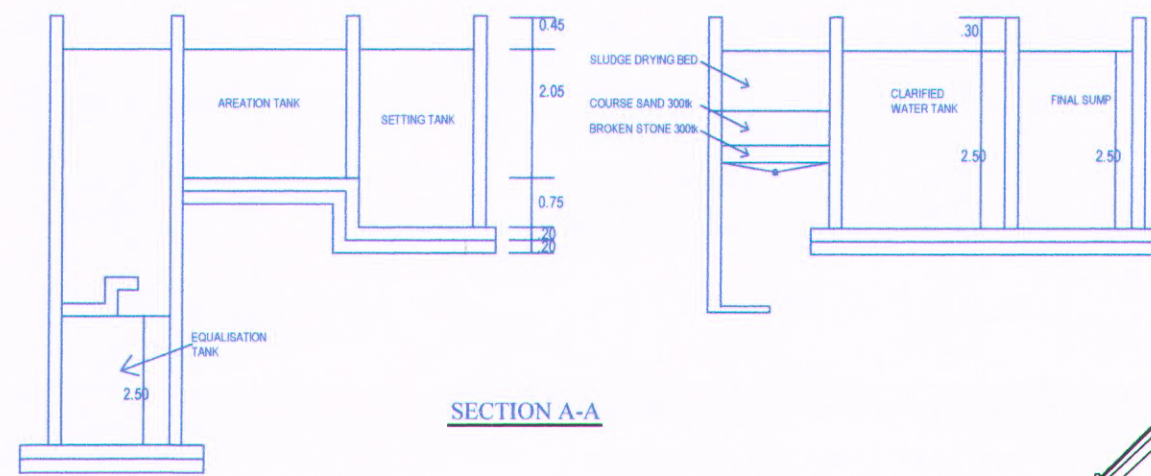




PLAN SHOWING THE R.W.H ,SOLAR SEPTIC TANK , AND S.T.P DETAILS FOR THE EXISTING AND PROPOSED CONSTRUCTION OF HOSPITAL BUILDING IN S.NO :100/2 AT PALLATHUR VILLAGE , PALLATHUR TOWN PANCHAYAT, KARAUKUDI TALUK,SIVAGANGAI DISTRICT.

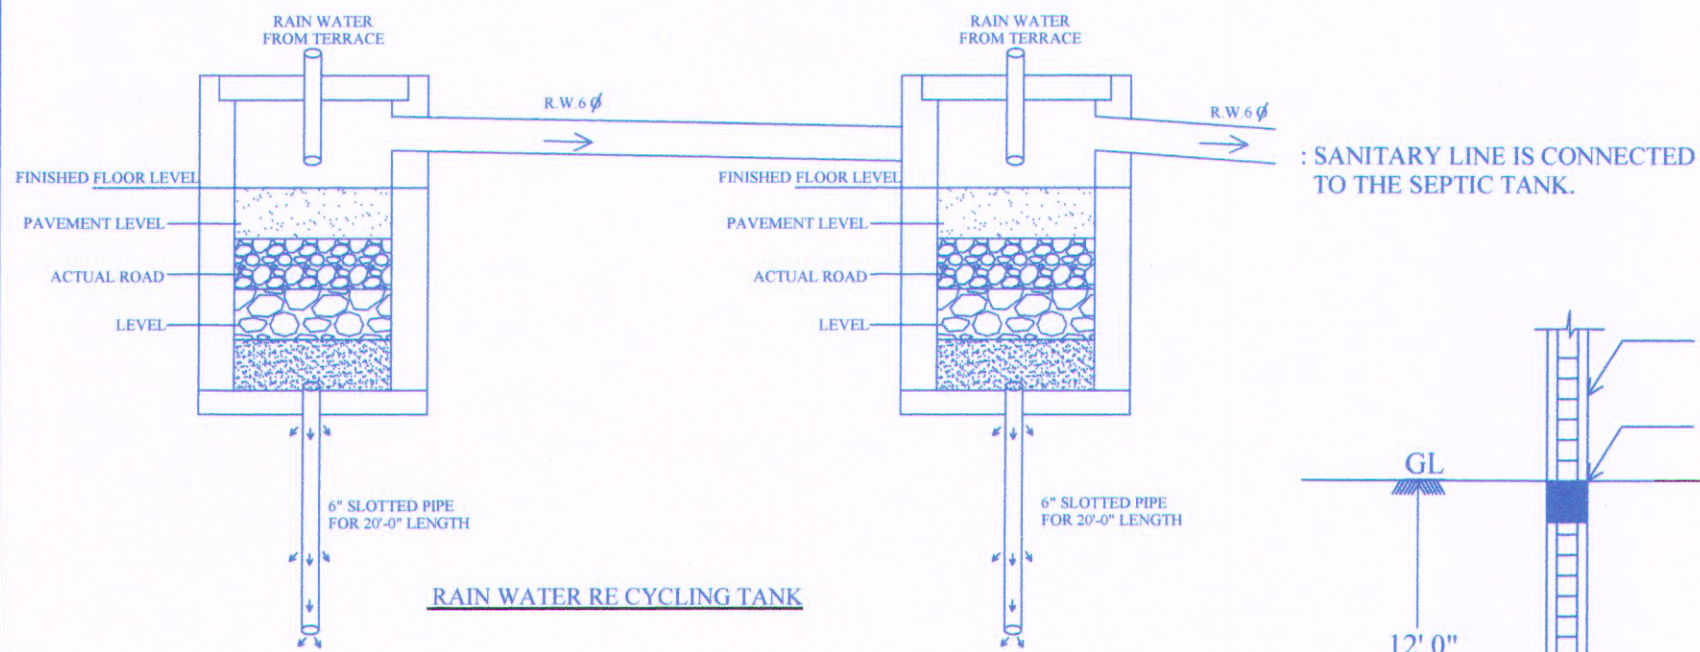


Compound Wall & Gate Details

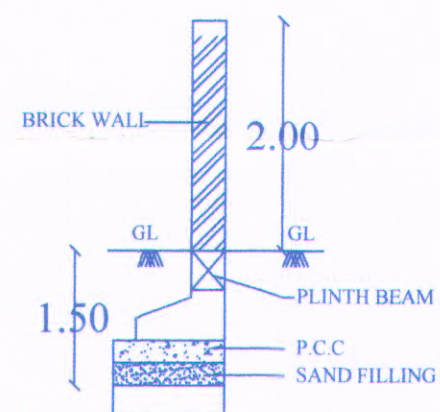


Section

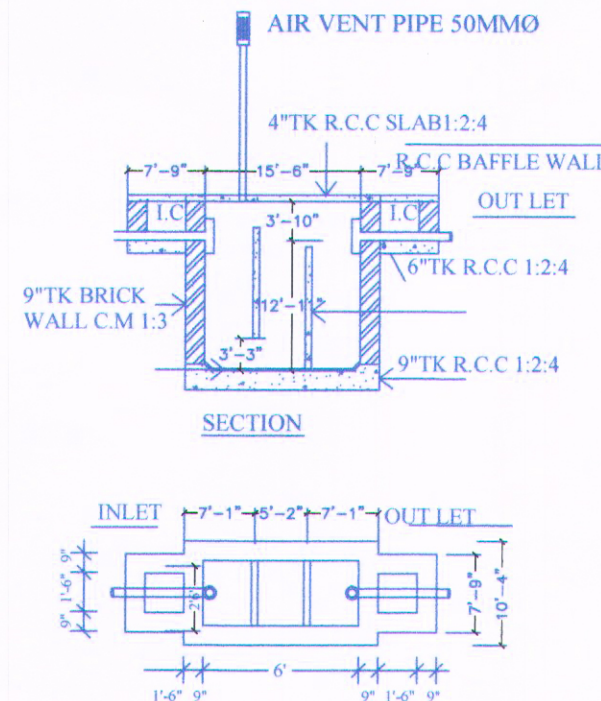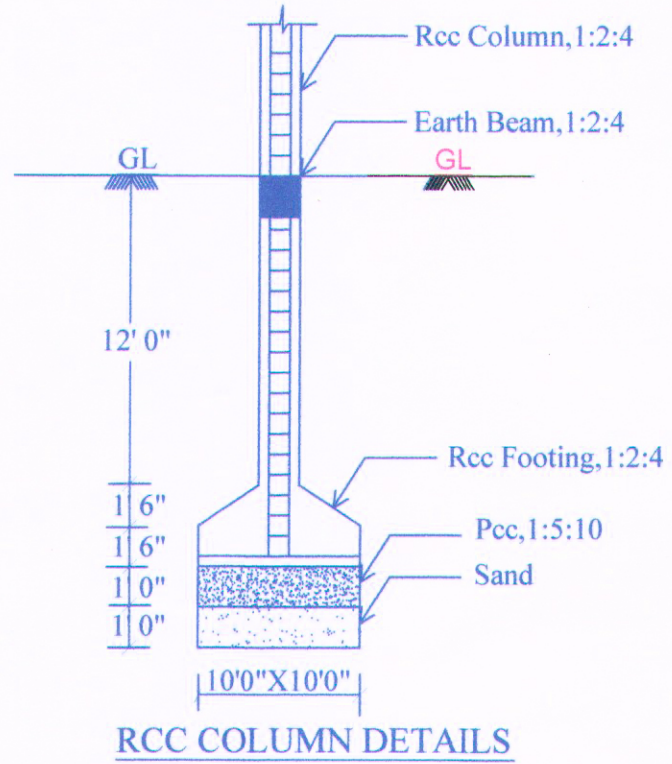


PLAN
SEPTIC TANK DETAILS
SCALE 1"=8'0"

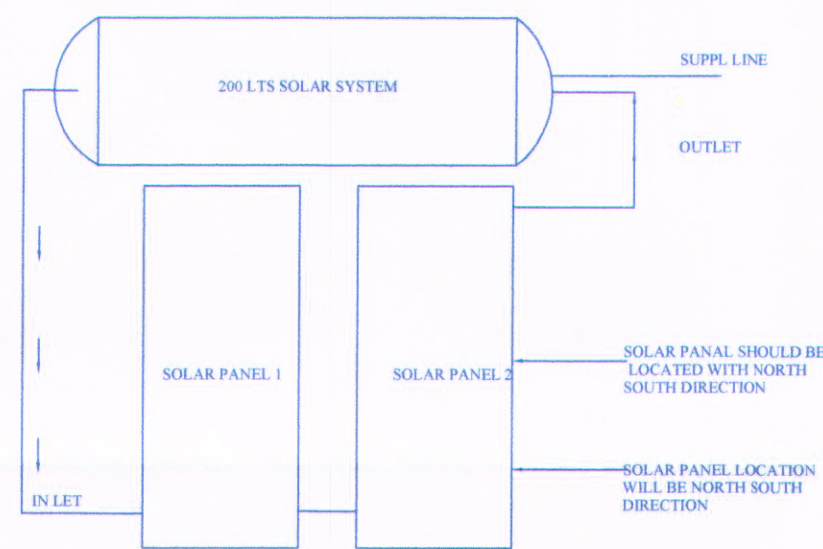


200 LTS SOLAR SYSTEM (TYP) INDIVIDUAL HOUSES
SCALE:1:50

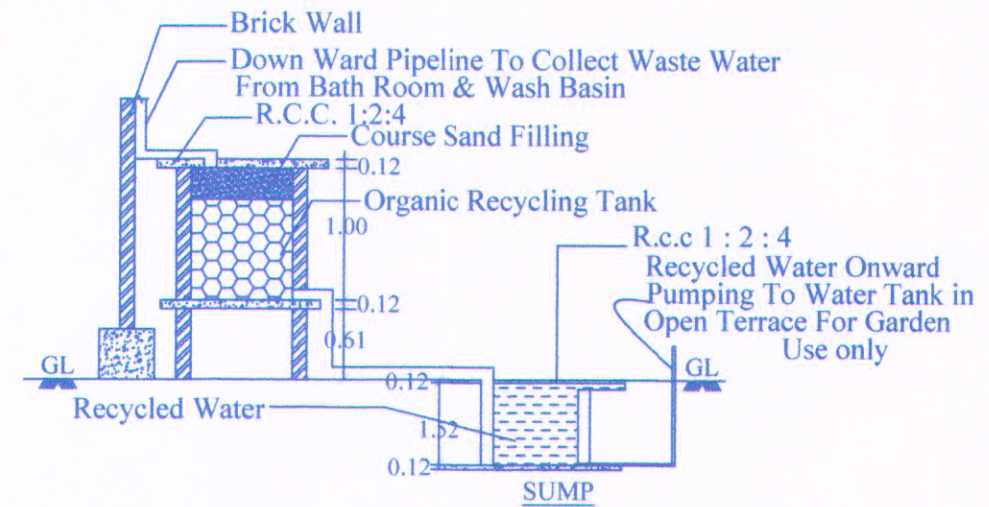


DETAILS FOR BATH ROOM WASTE
WATER FILTRATION SYSTEM & SUMP

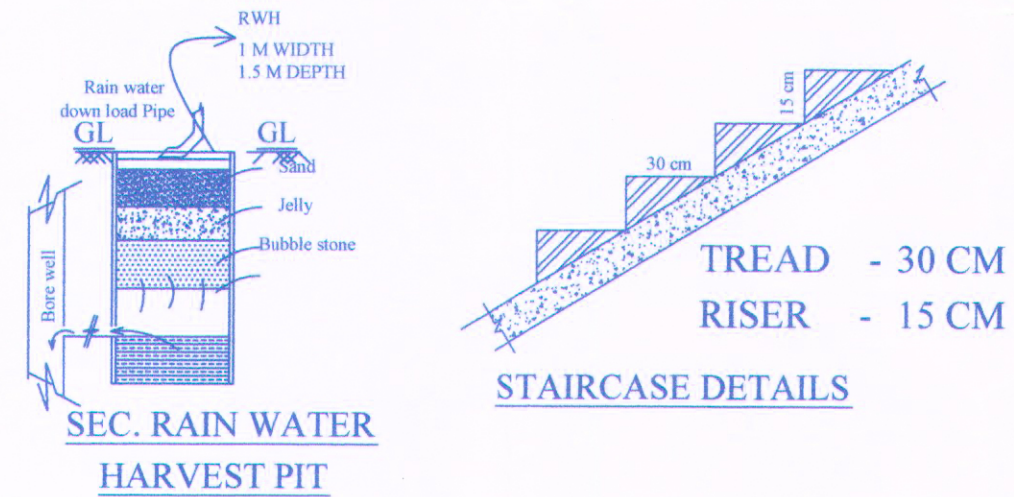

SEC. RAIN WATER HARVEST PIT

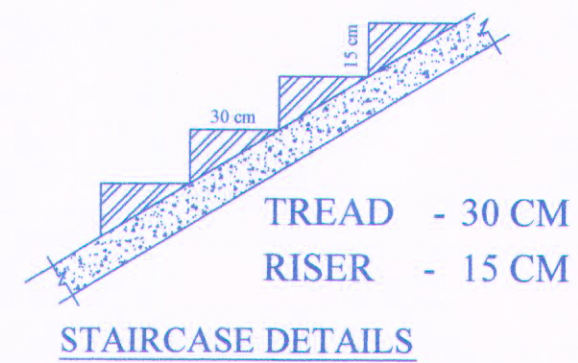


STAIRCASE DETAILS

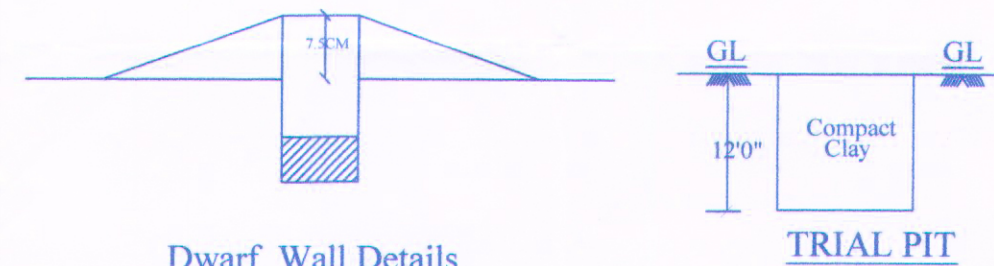


Dwarf Wall Details

TRIAL PIT

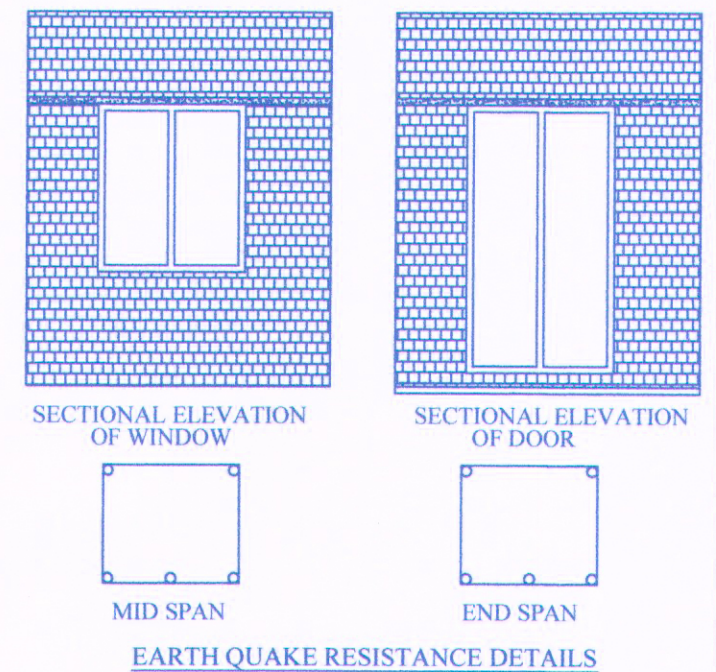

EARTH QUAKE RESISTANCE DETAILS

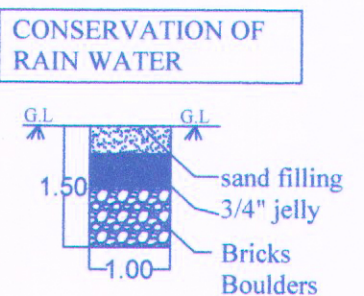

CONSERVATION OF RAIN WATER

ARCHITECT


R. GURUNATHAN B.Arch.
REGISTERED ARCHITECT GR - I
RA / GR-I / 19 / 03 / 081
22, Padmanabha Nagar 3rd Street
Adyar, Chennai - 600 020
Tel: 044 - 2491 2412

For A


For A.M.M. FOUNDATION

Authorised Signatory


APPLICANT

Er.V. XAVIER ANTONY RAJ, M.E.,
DTCP Civil Engineer RE/Gr.1/SVG Region/0016/2019
DTCP Structural Engineer SE/Gr.1/SVG Region/007/2020,
Karaikudi Municipality Regd. Engineer/Gr.1/11/15/2019/00015,
VEE'X CONSULTANTS
16/2, Valluvar Salai ,
Thilagar Nagar, KARAIKUDI-630 002.
Cell: 94430 92467.


REGISTERED ENGINEER/ARCHITECT

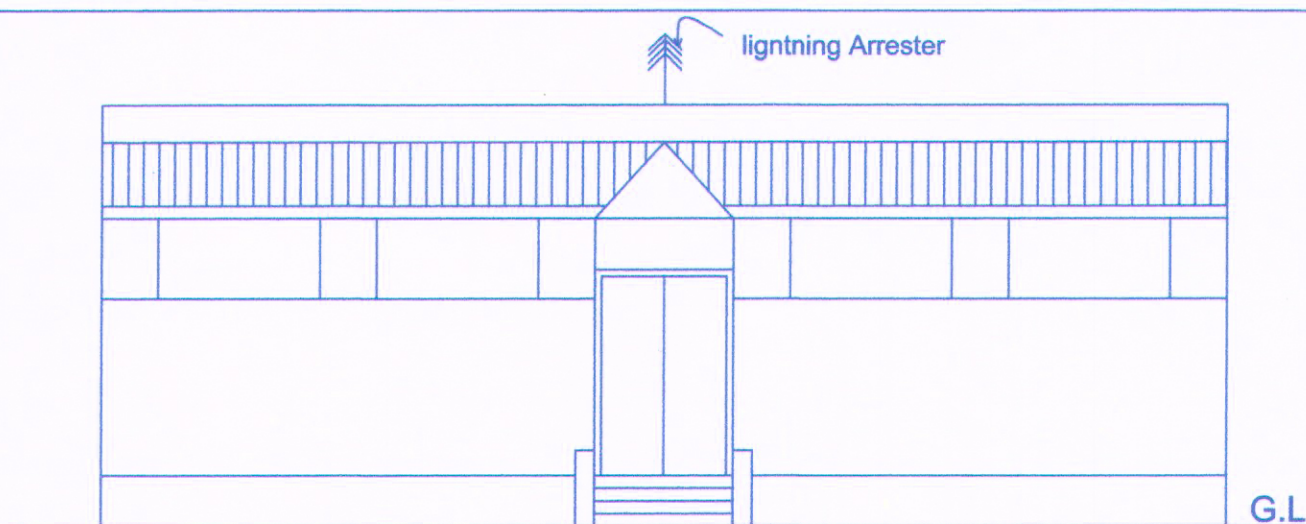


**ELEVATION
(BLOCK-6)**

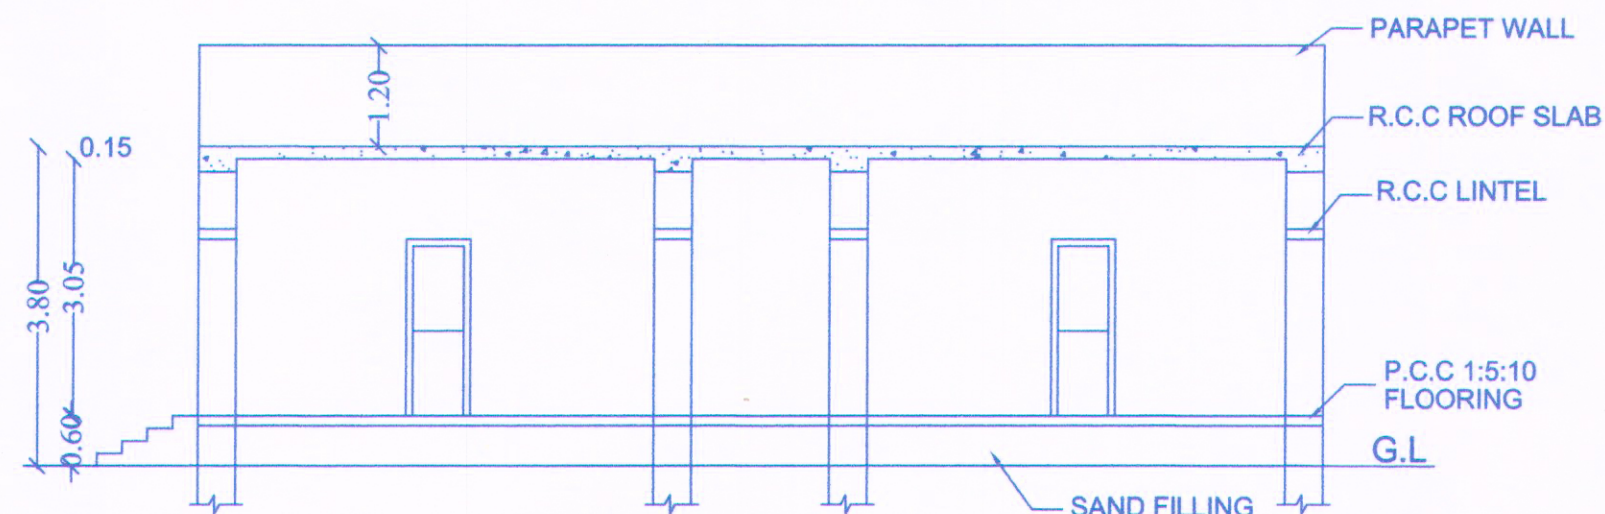

**SECTION ON - AA
(BLOCK-6)**

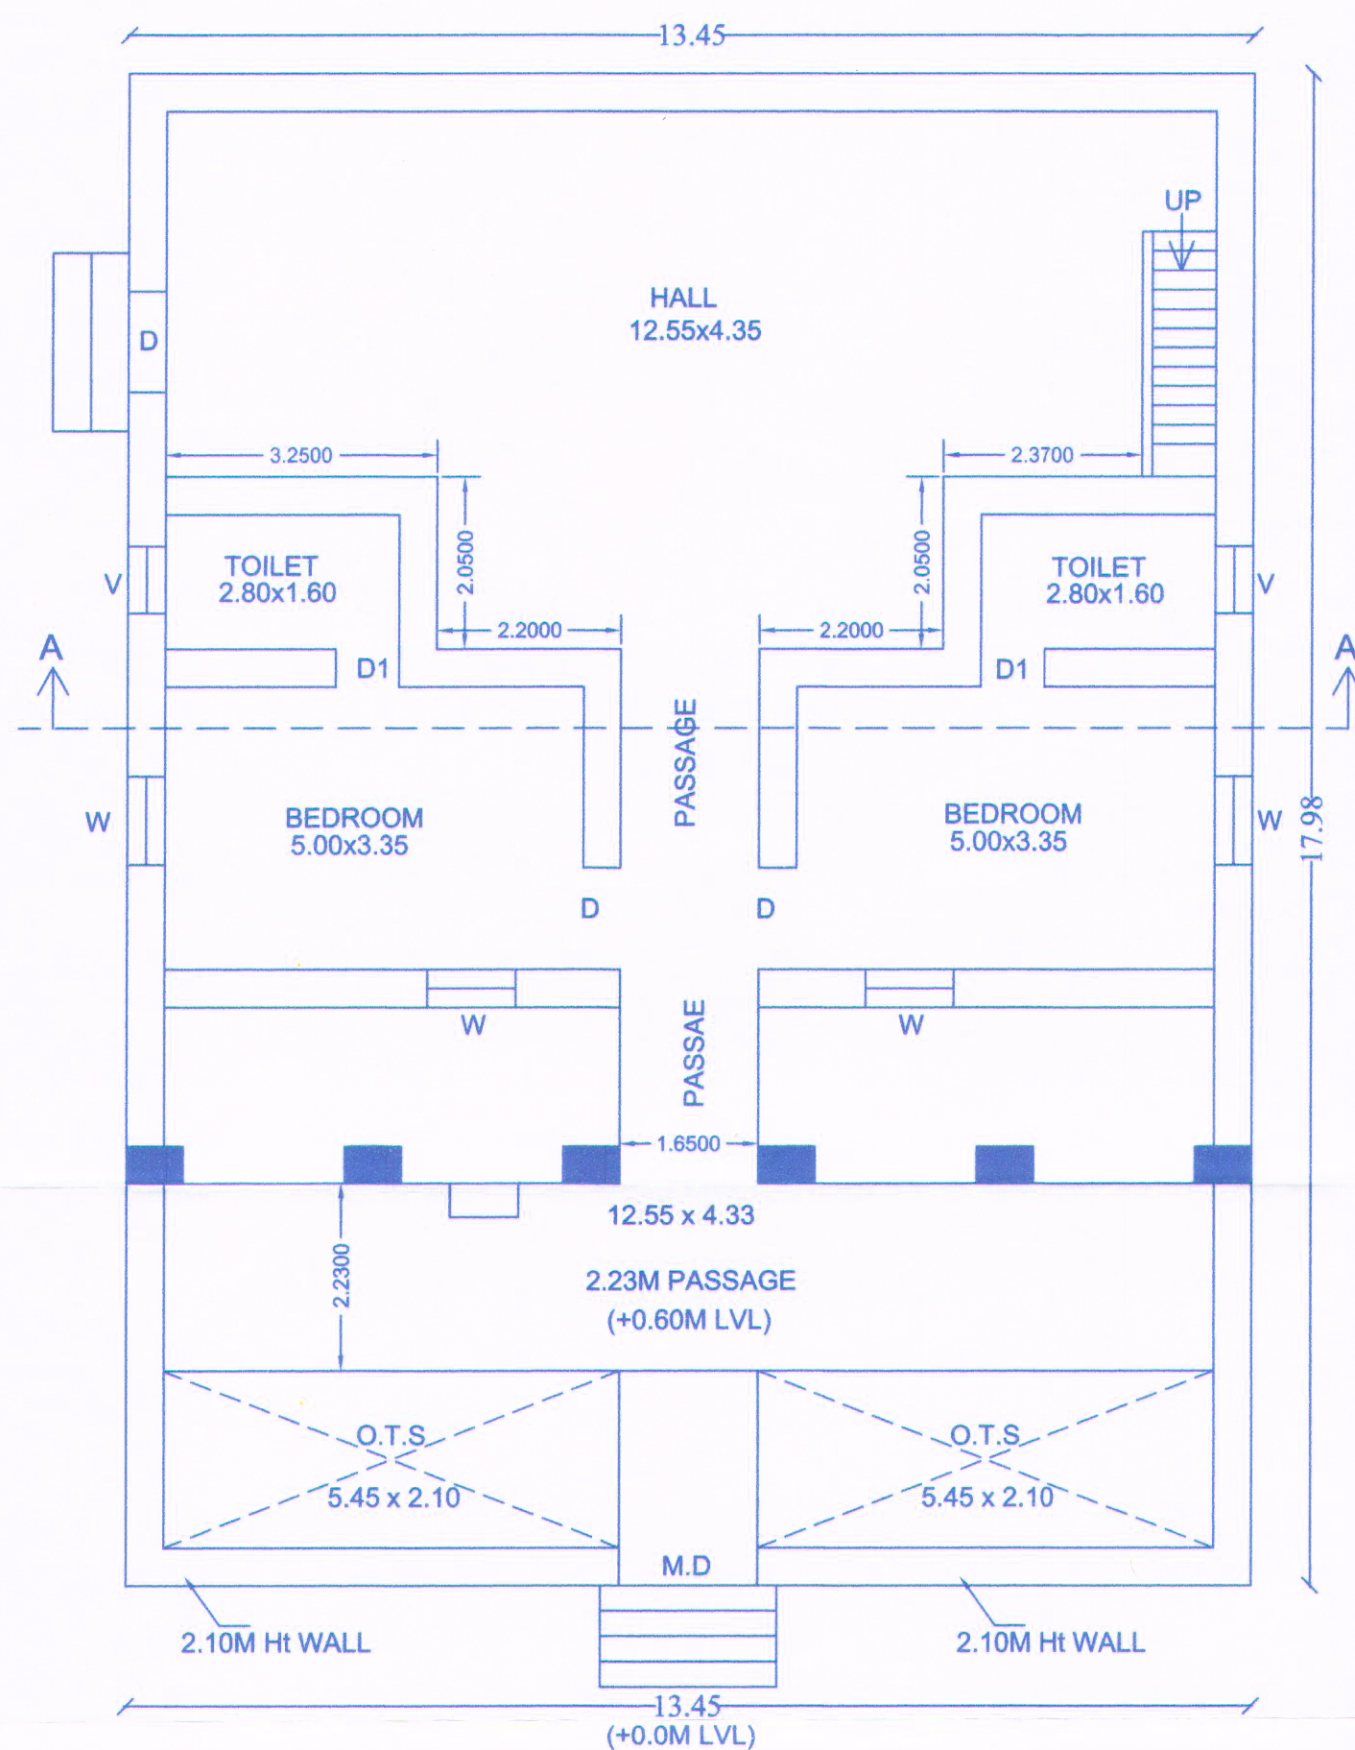

**GROUND FLOOR PLAN
(BLOCK-6)**

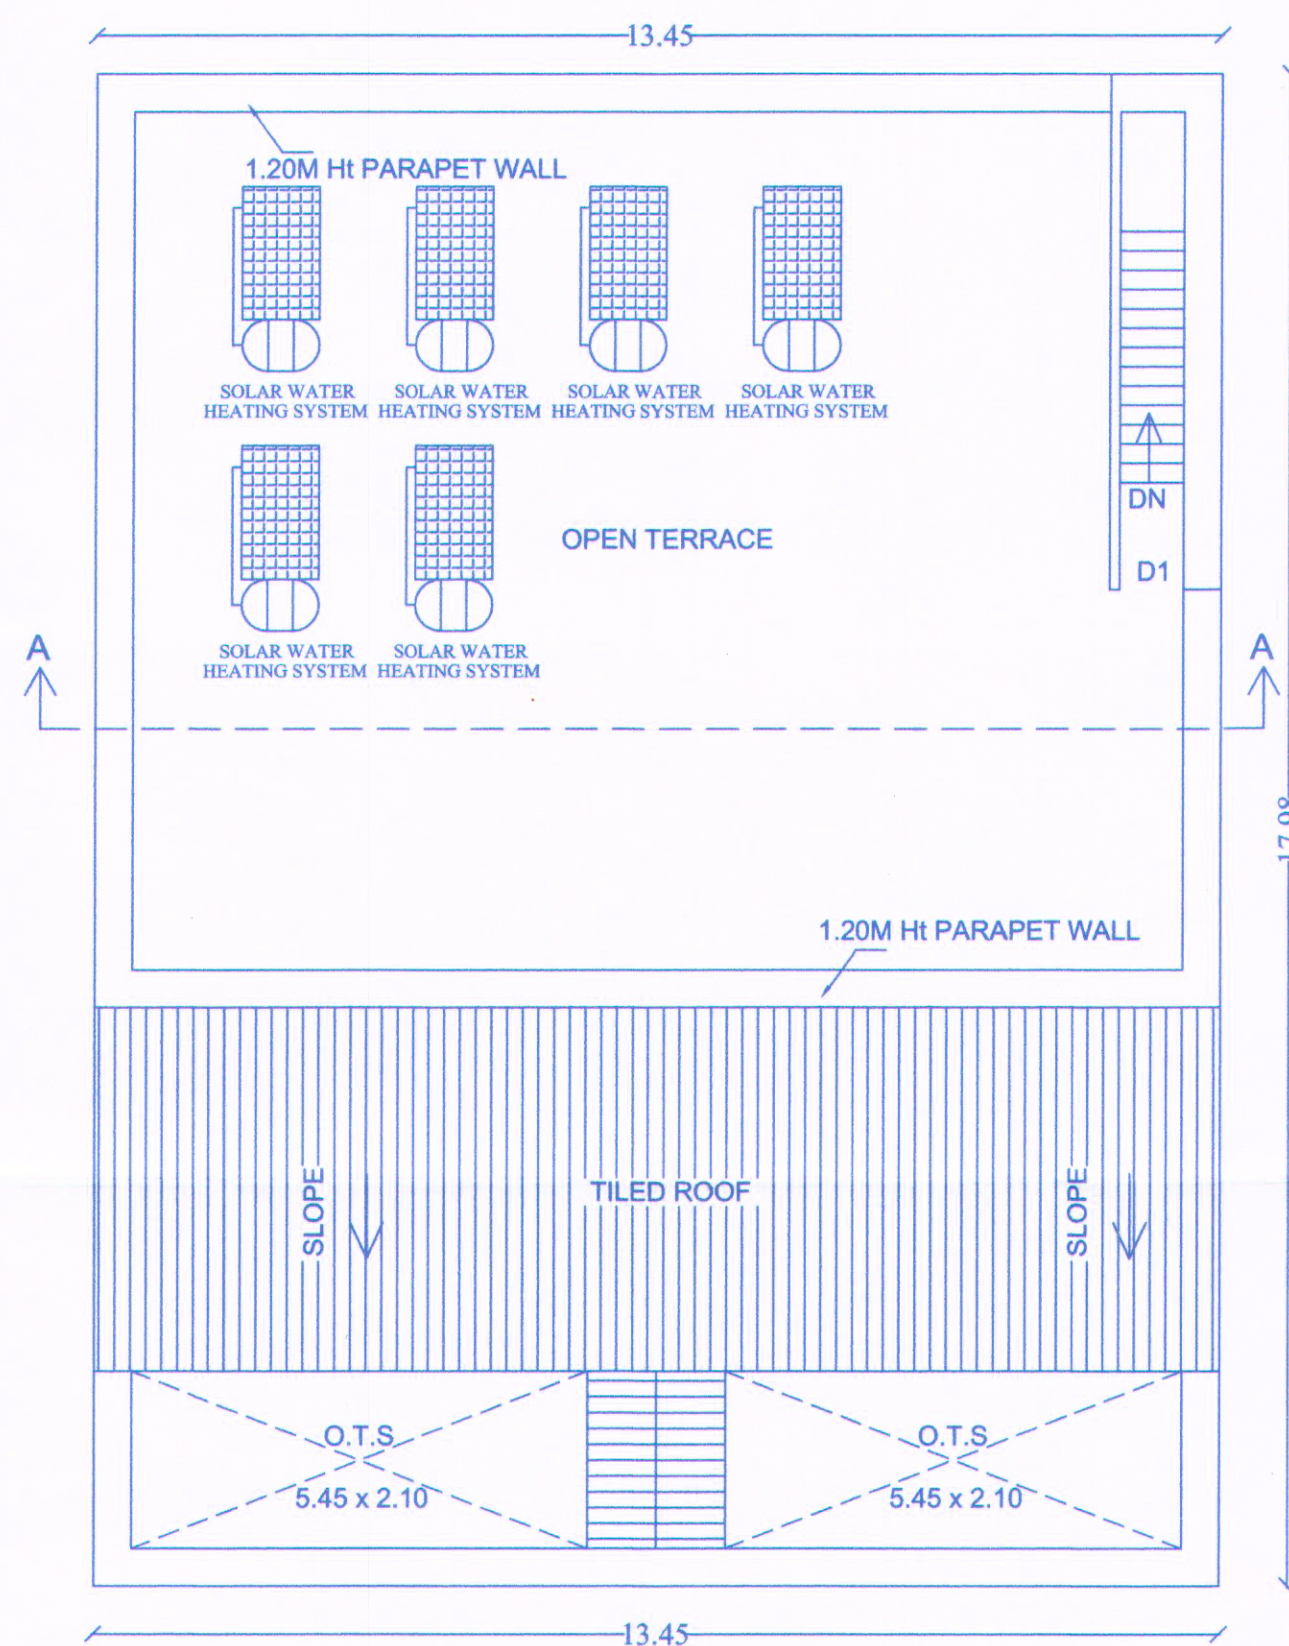

**TERRACE FLOOR PLAN
(BLOCK-6)**

**PLAN SHOWING THE EXISTING
AND PROPOSED CONSTRUCTION
OF HOSPITAL BUILDING IN S.NO :100/2
AT PALLATHUR VILLAGE , PALLATHUR
TOWN PANCHAYAT, KARAUKUDI TALUK,
SIVAGANGAI DISTRICT. (SCALE-1:100)**

JOINERY DETAILS

M.D	MAIN DOOR	1.65 x 2.44
D	DOOR	1.20 x 2.10
D1	DOOR	0.76 x 2.10
W	WINDOW	1.05 x 1.35
V	VENTILATOR	0.80 x 0.80

AREA DETAILS

Descriptions	Non FSI (Sq.M)	FSI (Sq.M)	Total Area (Sq.M)
Area of the Ground Floor (Block-06)		241.83	241.83
Total Area		241.83	241.83

NOTE:

ALL DIMENSIONS ARE IN 'M'

In all rooms-Mechanical ventilation to be provided

In all rooms-fire safety measures to be provided

Er.V.XAVIER ANTONY RAJ, M.E.,
DTCP Civil Engineer RE/Gr.1/SVG Region/0016/2019
DTCP Structural Engineer SE/Gr.1/SVG Region/007/2020,
Karaikudi Municipality Regd.Engineer, Gr-1/111/LS/2019/00015,
VEE'X CONSULTANTS
16/2, Valluvar Salai,
Thilagar Nagar, KARAUKUDI-630 002.
Cell: 94430 92467.
E.mail:vee.x.consultants@gmail.com
STRUCTURAL ENGINEER

For A.M.M. FOUNDATION

Authorised Signatory



R. GURUNATHAN B.Arch.
REGISTERED ARCHITECT GR - I
RA / GR-1 / 19 / 03 / 081
22, Padmanabha Nagar 3rd Street
Adyar, Chennai - 600 020
Tel: 044 - 2491 2412

APPLICANT

REGISTERED ENGINEER/
ARCHITECT

PLAN SHOWING THE EXISTING AND PROPOSED CONSTRUCTION OF HOSPITAL BUILDING IN S.NO :100/2 AT PALLATHUR VILLAGE , PALLATHUR TOWN PANCHAYAT, KARAUKUDI TALUK, SIVAGANGAI DISTRICT.

(SCALE-1:100)

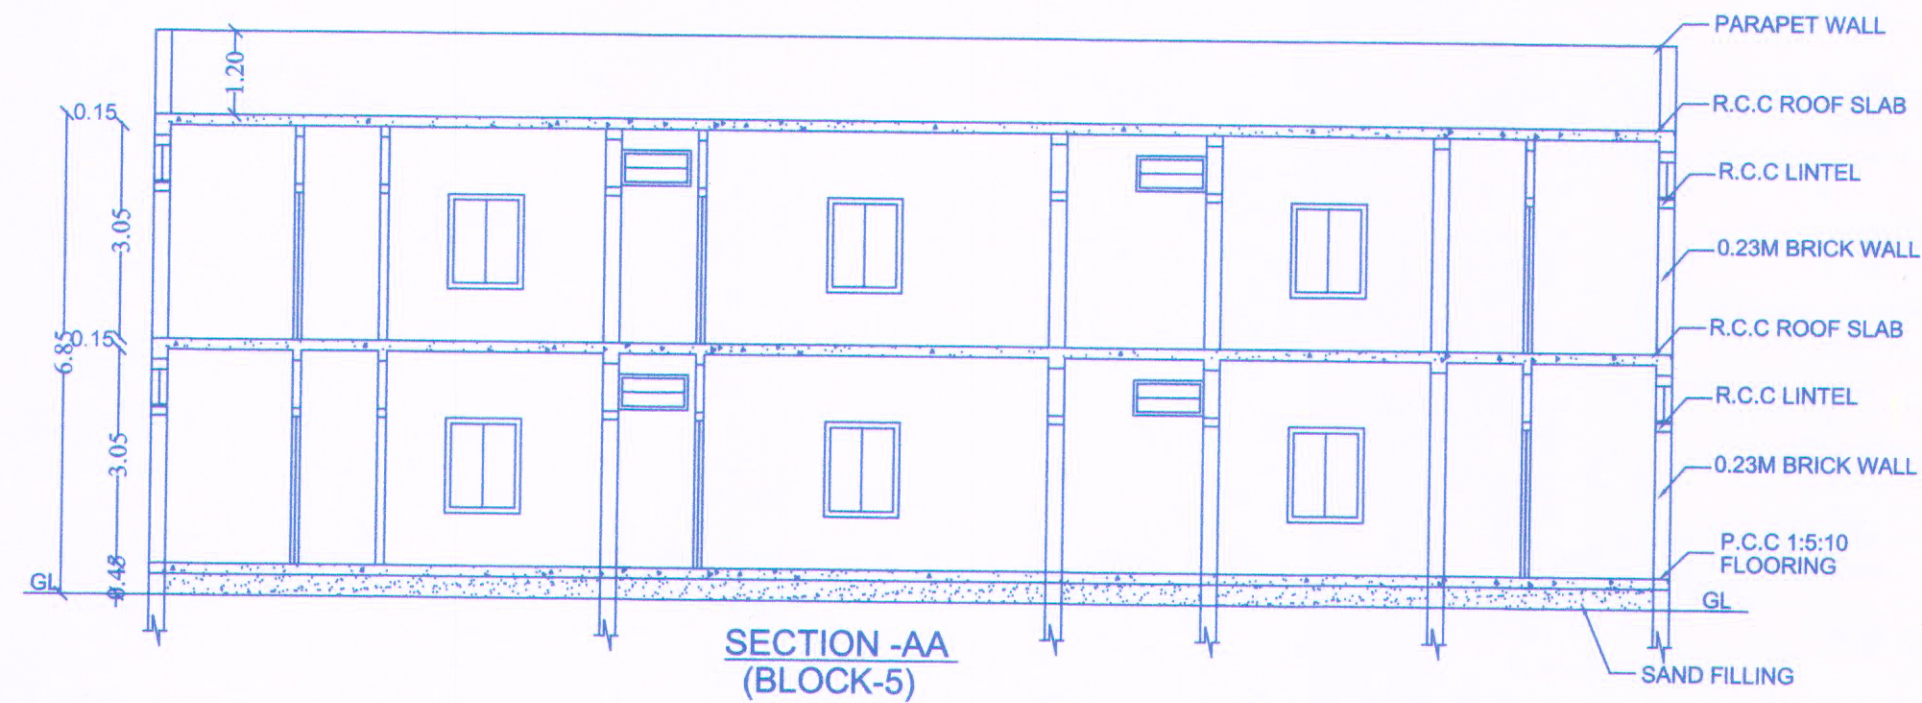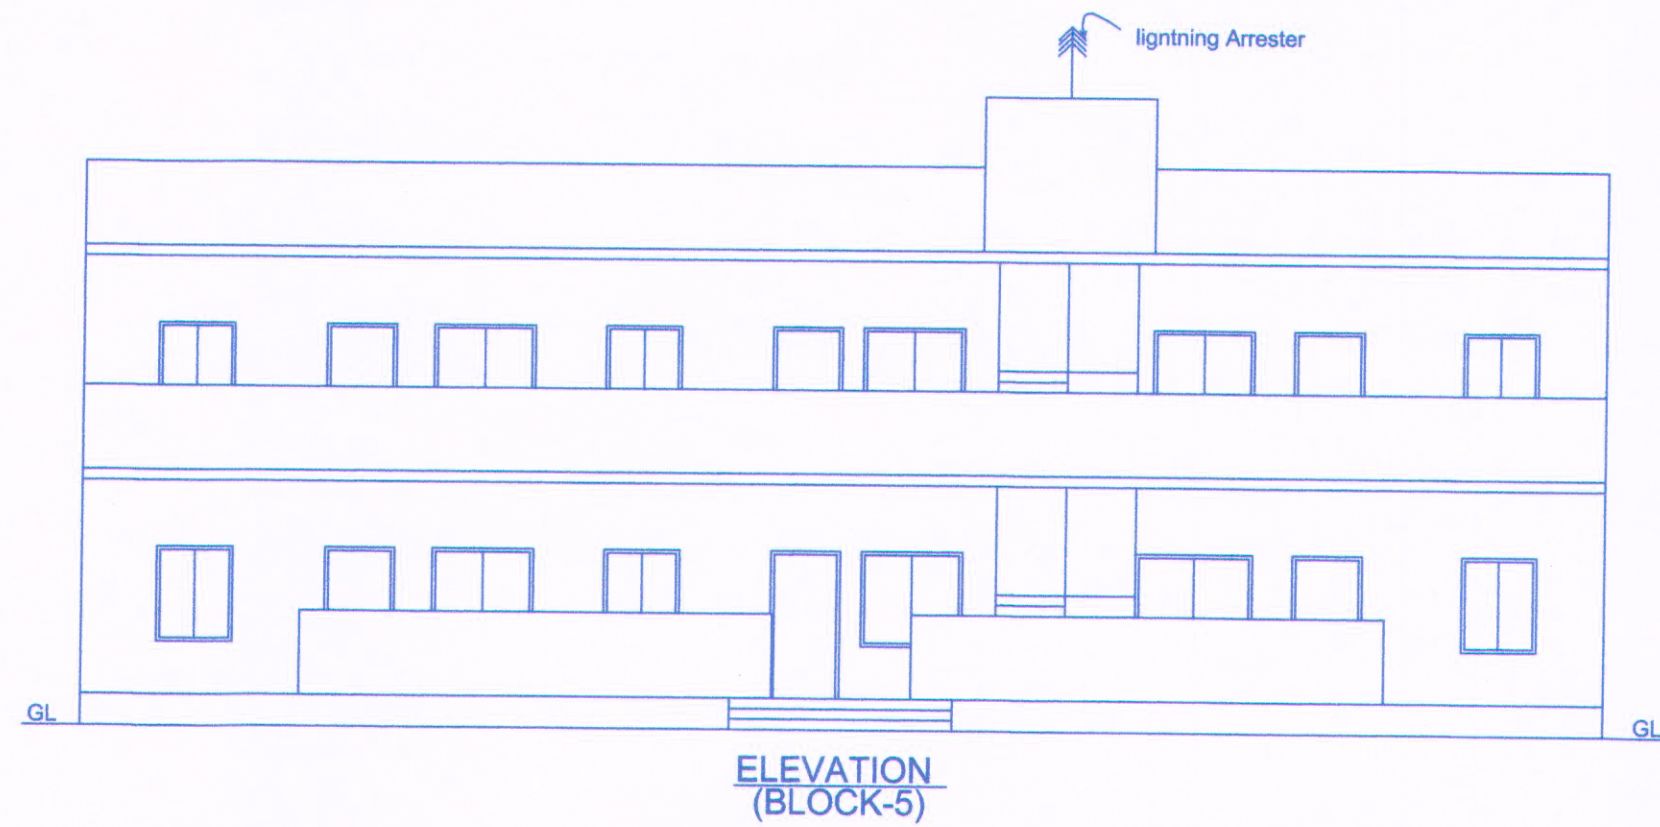

JOINERY DETAILS

D	DOOR	1.20 x 2.10
D1	DOOR	0.76 x 2.10
W	WINDOW	1.70 x 1.35
W1	WINDOW	1.20 x 1.35
V	WINDOW	0.90 x 0.76

AREA DETAILS




Descriptions	Non FSI (Sq.M)	FSI (Sq.M)	Total Area (Sq.M)
Area of the Ground Floor (Block-5)		149.43	149.43
Area of the First Floor (Block-5)		149.43	149.43
Area of the Head Room (Block-5)	12.74		12.74
Total Area	12.74	298.86	311.60

NOTE:

ALL DIMENSIONS ARE IN 'M'

In all rooms-Mechanical ventilation to be provided

In all rooms-fire safety measures to be provided

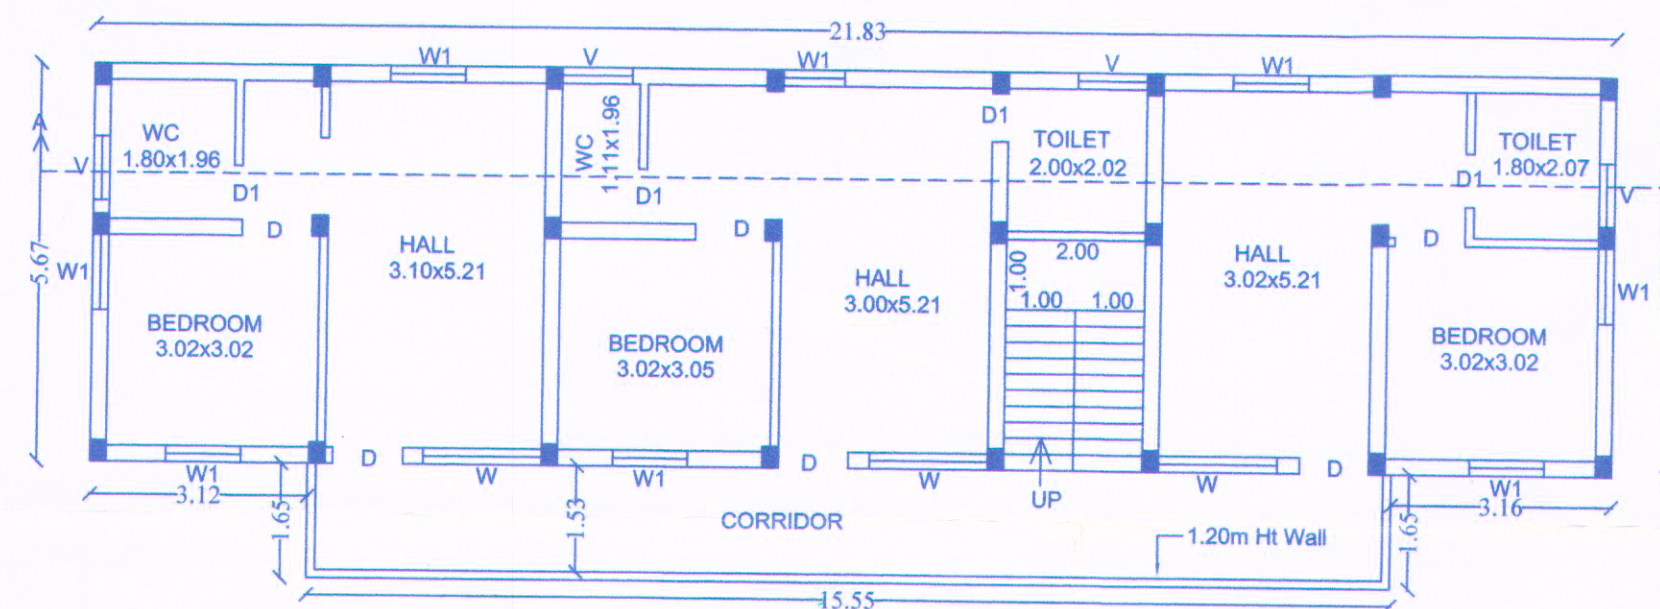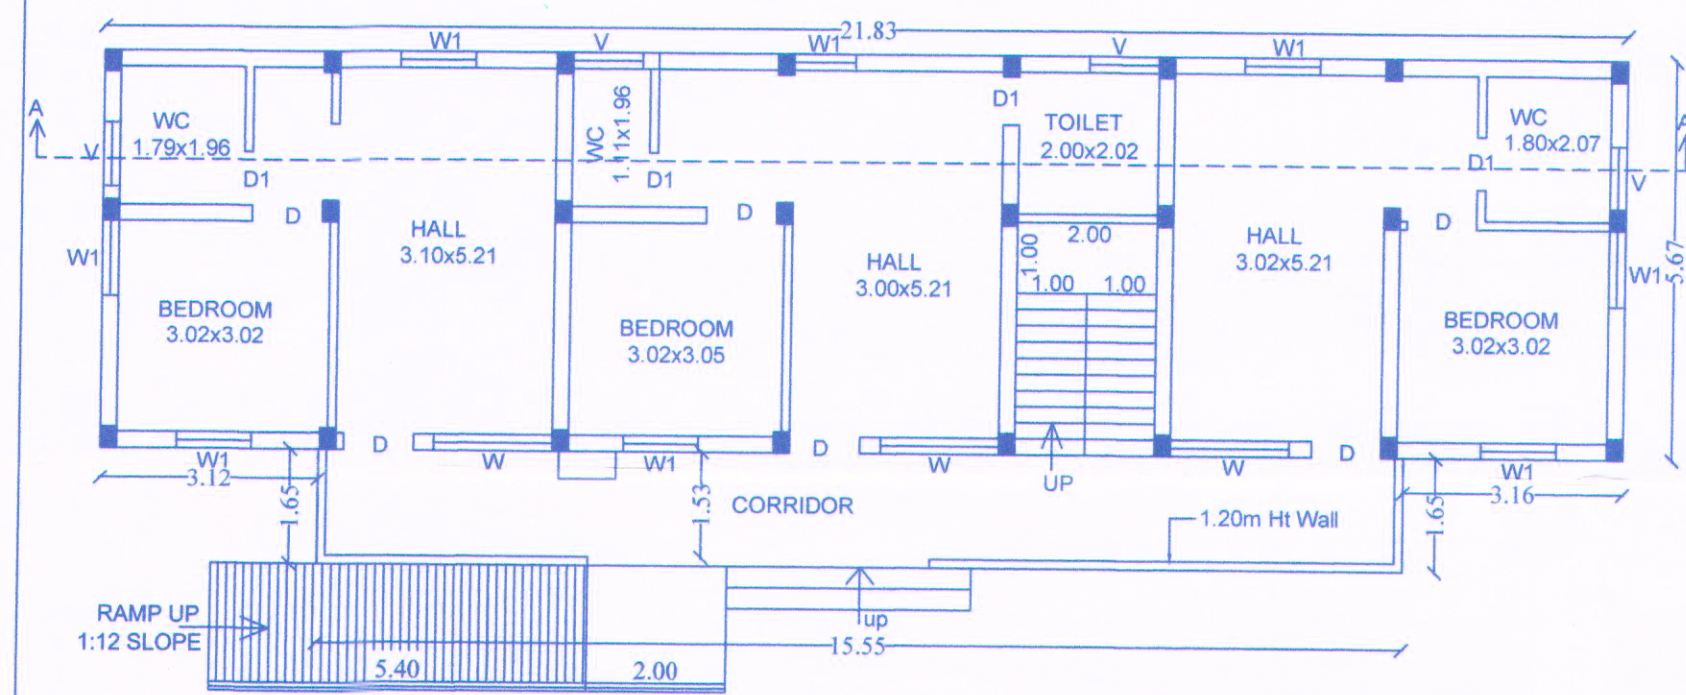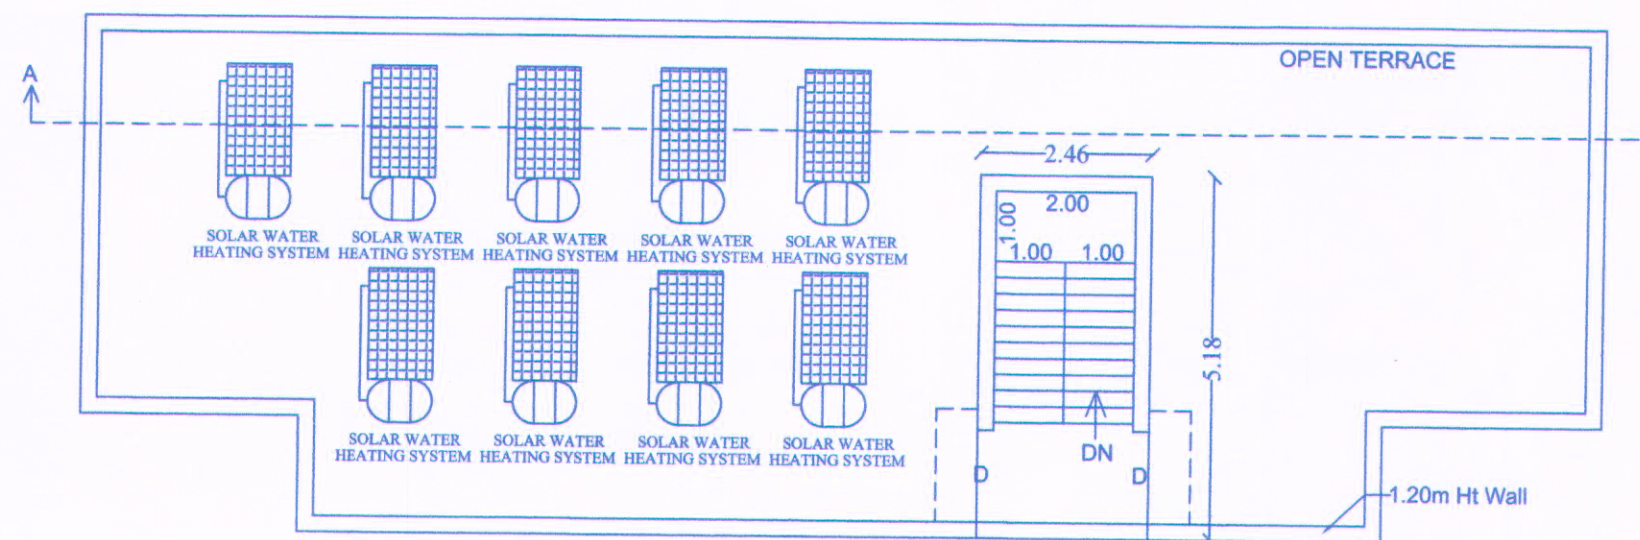

Er.V.XAVIER ANTONY RAJ, M.E.,

DTCP Civil Engineer RE/Gr.1/SVG Region/0016/2019

DTCP Structural Engineer SE/Gr.1/SVG Region/007/2020,

Karaikudi Municipality Regd. Engineer. Gr.1/111/LS/2019/00015,

VEE'X CONSULTANTS

16/2, Valluvar Salai,

Thilagar Nagar, KARAUKUDI-630 002.

Cell: 94430 92467.

Email: vee_x_consultants@gmail.com


STRUCTURAL ENGINEER

For A.M.M. FOUNDATION


Authorised Signatory

R. GURUNATHAN B.Arch.
REGISTERED ARCHITECT GR - I
RA/GR-1/19/03/081
22, Padmanabha Nagar 3rd Street
Adyar, Chennai - 600 020
Tel: 044 - 2491 2412
REGISTERED ENGINEER/
ARCHITECT


APPLICANT

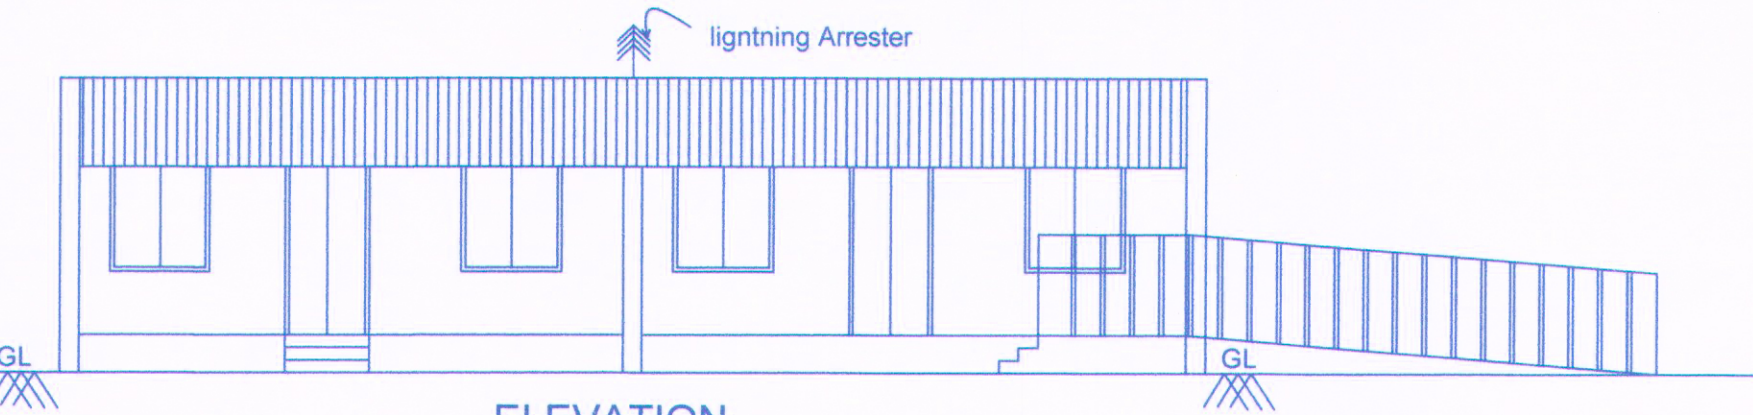


ELEVATION
(BLOCK-4)

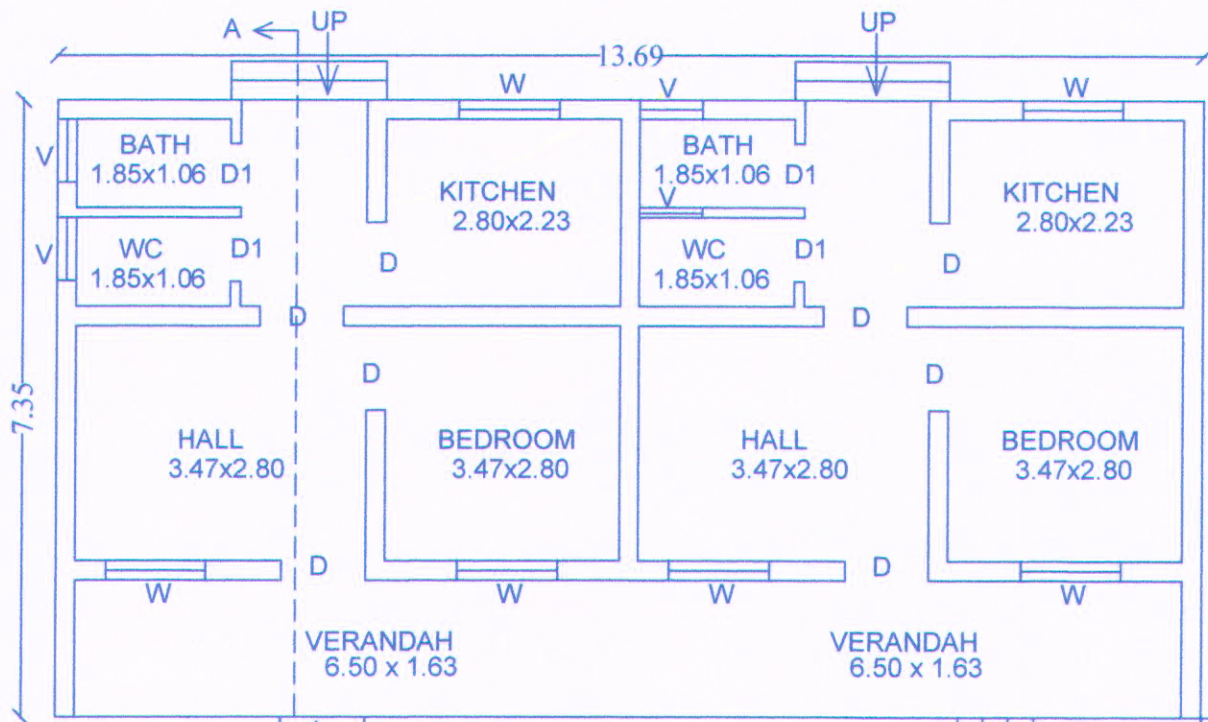

GROUND FLOOR PLAN
(BLOCK-4)

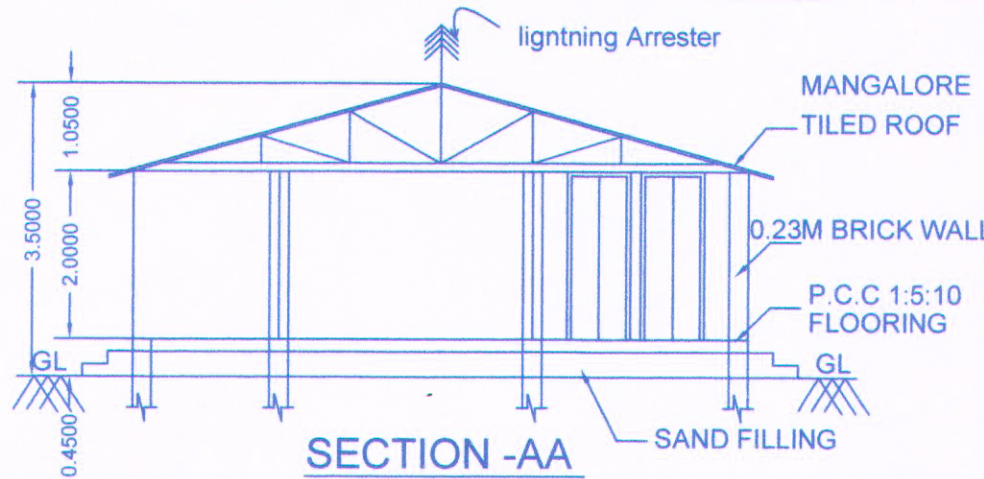

SECTION -AA
(BLOCK-4)

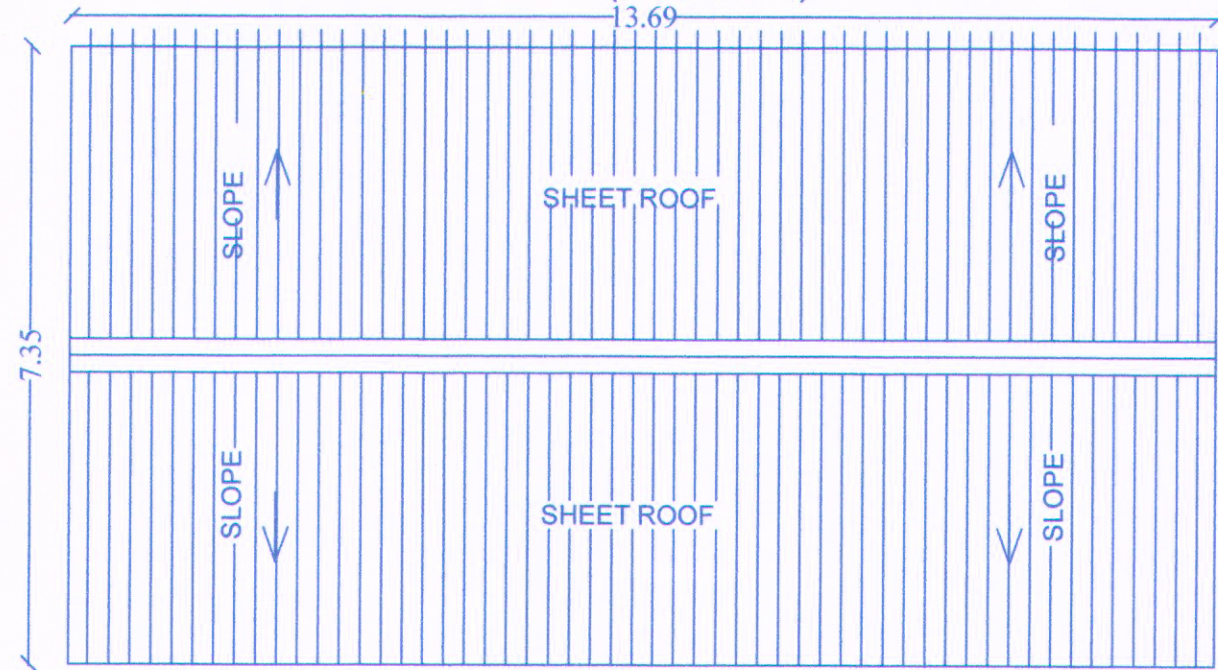

ROOF PLAN
(BLOCK-4)

PLAN SHOWING THE EXISTING
AND PROPOSED CONSTRUCTION
OF HOSPITAL BUILDING IN S.NO :100/2
AT PALLATHUR VILLAGE , PALLATHUR
TOWN PANCHAYAT, KARAUKUDI TALUK,
SIVAGANGAI DISTRICT.

SHEET NO:06

(SCALE-1:100)

D	DOOR	1.20 x 2.10
D1	DOOR	0.76 x 2.10
W	WINDOW	1.70 x 1.35
V	WINDOW	1.70 x 0.76

AREA DETAILS

Descriptions	Non FSI (Sq.M)	FSI (Sq.M)	Total Area (Sq.M)
Area of the Ground Floor (Block-4)		100.62	100.62
TOTAL AREA		100.62	100.62

NOTE:

ALL DIMENSIONS ARE IN 'M'

In all rooms-Mechanical ventilation to be provided

In all rooms-fire safety measures to be provided

OFFICE USE

Er.V.XAVIER ANTONY RAJ, M.E.,
STRUCTURAL ENGINEER,
Registered Engineer Grade-I,
Regd No 111/LS/2019/00015,
VEE'X CONSULTANTS
16/2, Valluvar Salai ,
Thilagar Nagar, KARAUKUDI-630 002.
Cell: 94430 92467,
E.mail:vee.x.consultants@gmail.com

STRUCTURAL ENGINEER

For A.M.M. FOUNDATION

Authorised Signatory

APPLICANT

R. GURUNATHAN B.Arch.
REGISTERED ARCHITECT GR - I
RA / GR-I / 19 / 03 / 081
22, Padmanabha Nagar 3rd Street
Adyar, Chennai - 600 020
Tel: 044 - 2491 2412

REGISTERED ENGINEER/
ARCHITECT

PLAN SHOWING THE EXISTING AND PROPOSED CONSTRUCTION OF HOSPITAL BUILDING IN S.NO :100/2 AT PALLATHUR VILLAGE , PALLATHUR TOWN PANCHAYAT, KARAUKUDI TALUK, SIVAGANGAI DISTRICT. (SCALE-1:100)

JOINERY DETAILS

D	DOOR	1.00 x 2.10
D1	DOOR	0.76 x 2.10
W	WINDOW	1.20 x 1.20
V	VENTILATOR	0.90 x 0.60

AREA DETAILS

Descriptions	Non FSI (Sq.M)	FSI (Sq.M)	Total Area (Sq.M)
Area of the Ground Floor (Block-3)		222.49	222.49
TOTAL AREA		222.49	222.49

NOTE:

ALL DIMENSIONS ARE IN 'M'
In all rooms-Mechanical ventilation to be provided
In all rooms-fire safety measures to be provided

Er.V.XAVIER ANTONY RAJ, M.E.,

DTCP Civil Engineer RE/Gr.1/SVG Region/0016/2019

DTCP Structural Engineer SE/Gr.1/SVG Region/007/2020,

Karaikudi Municipality Regd.Engineer.Gr-1/111/LS/2019/00015,

VEE'X CONSULTANTS

16/2, Valluvar Salai ,

Thilagar Nagar, KARAUKUDI-630 002.

Cell: 94430 92467.

Email: vee_x_consultants@gmail.com

STRUCTURAL ENGINEER

For A.M.M. FOUNDATION

Authorised Signatory

R. GURUNATHAN B.Arch.

REGISTERED ARCHITECT GR - I

RA/GR-I/19/03/081


22, Padmanabha Nagar 3rd Street

Adyar, Chennai - 600 020


Tel: 044 - 2491 2412

REGISTERED ENGINEER/ARCHITECT


APPLICANT

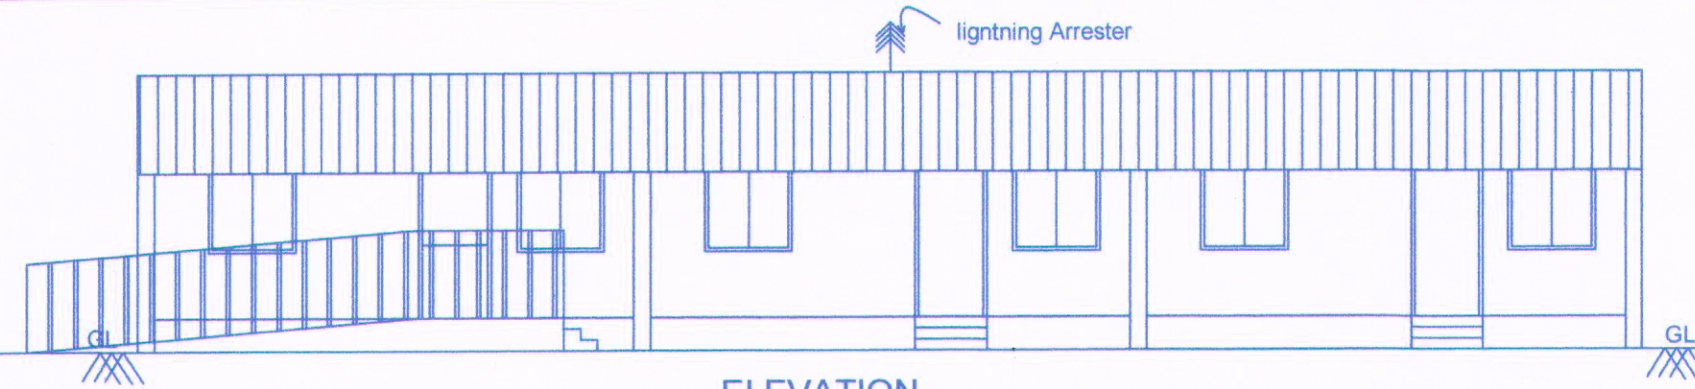


ELEVATION
(Block - 3)

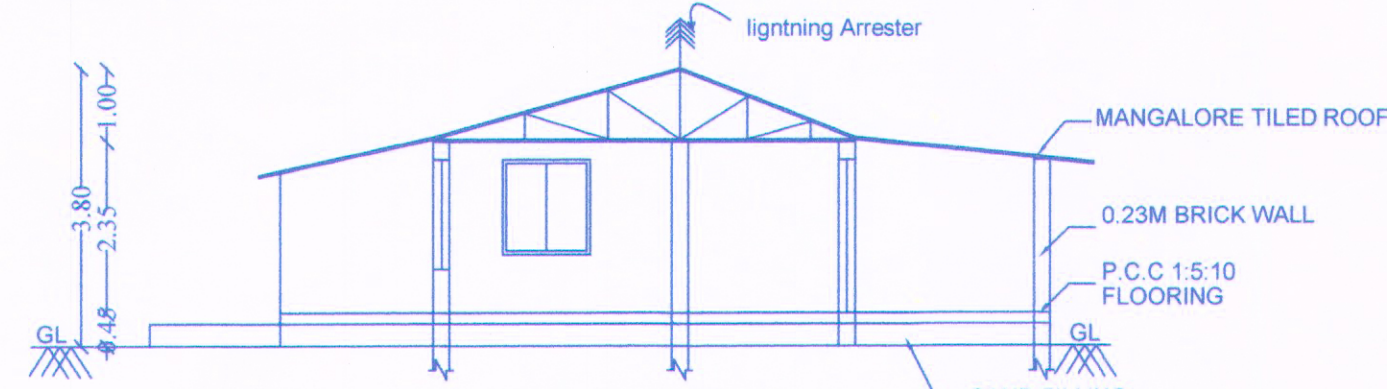


SECTION ON -AA
(Block - 3)

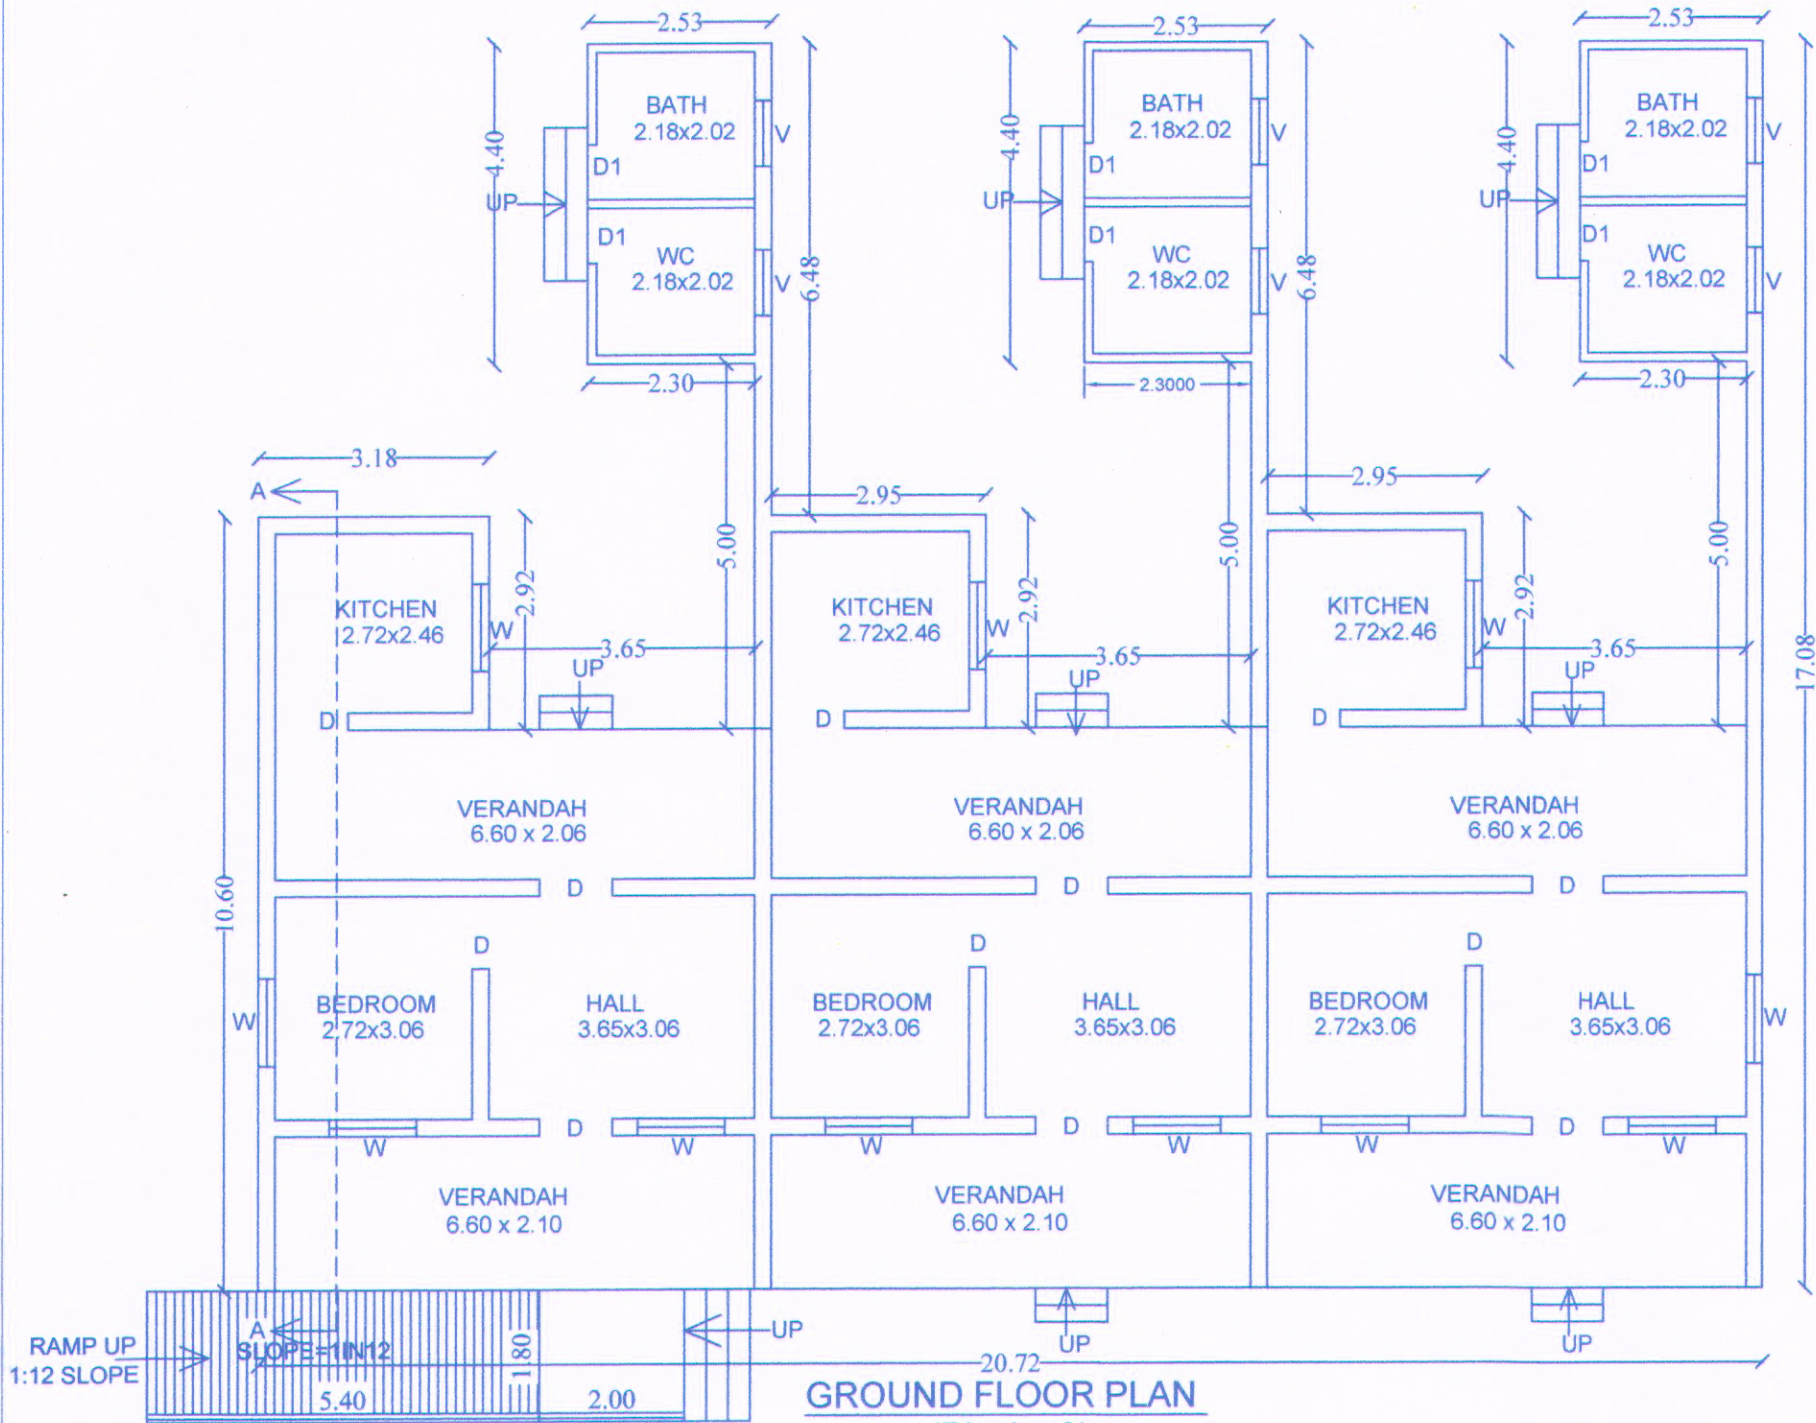


GROUND FLOOR PLAN
(Block - 3)

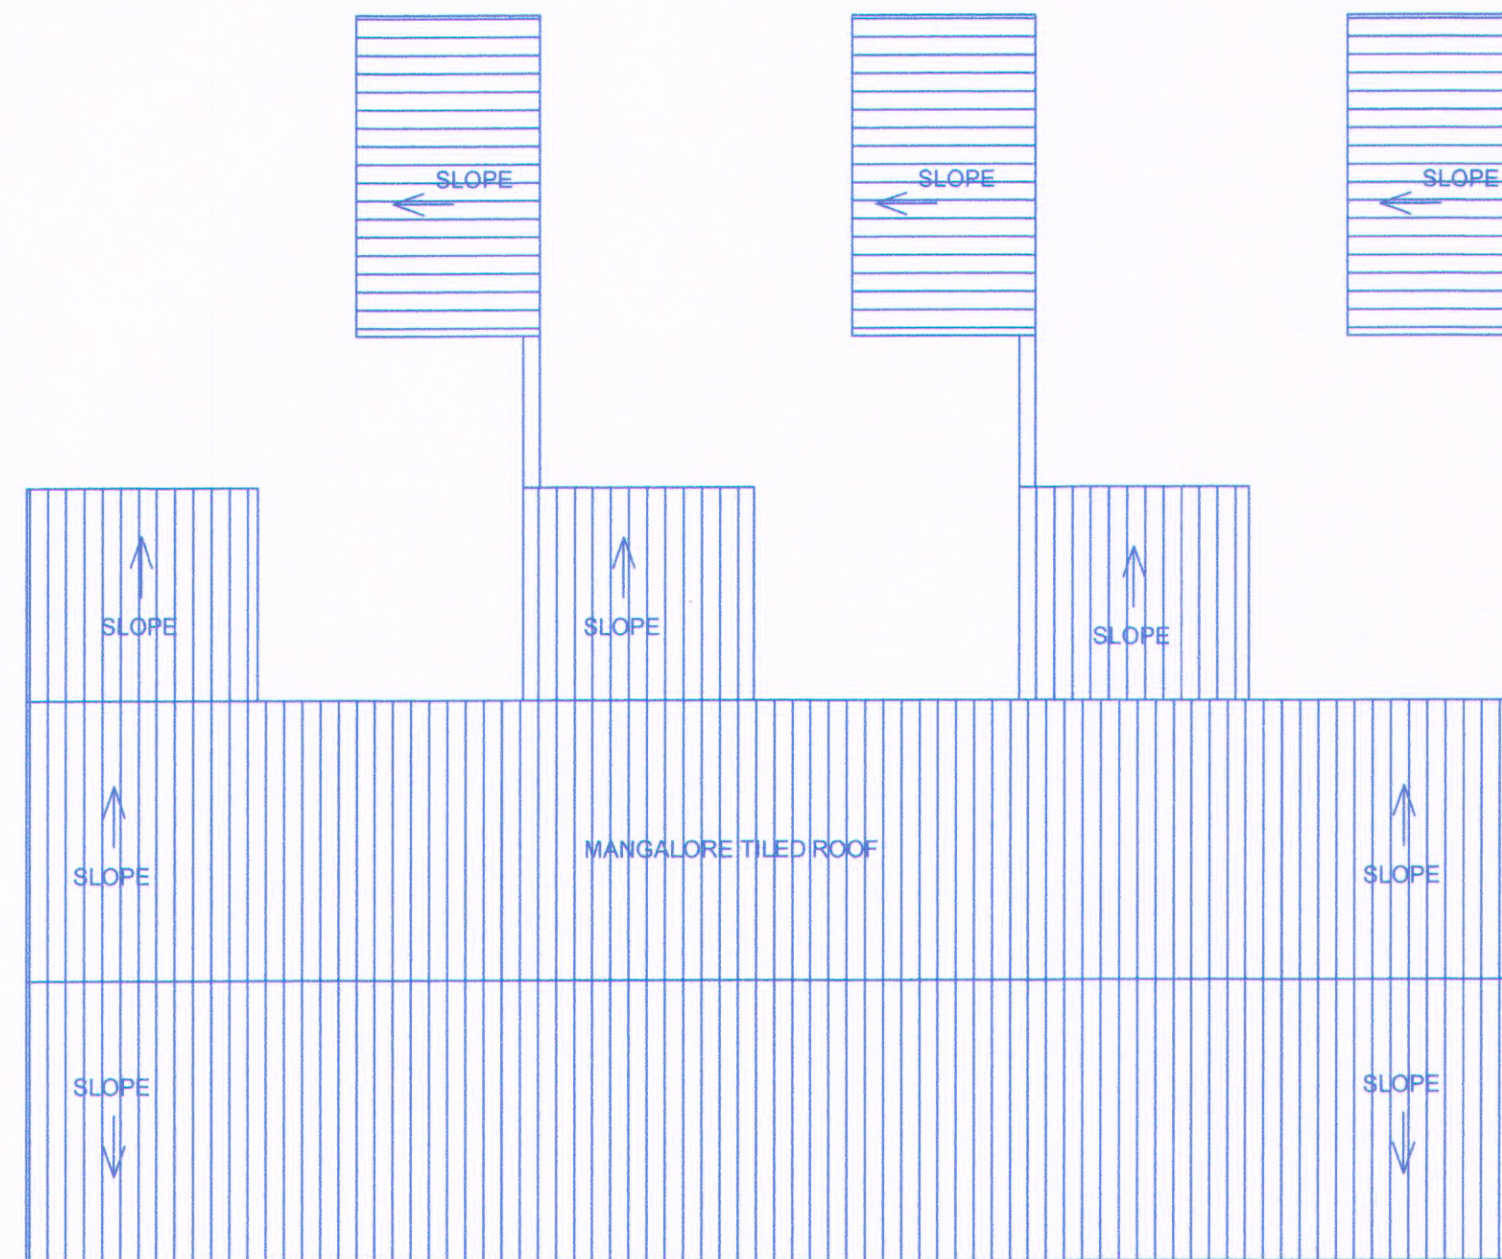


ROOF PLAN
(Block - 3)

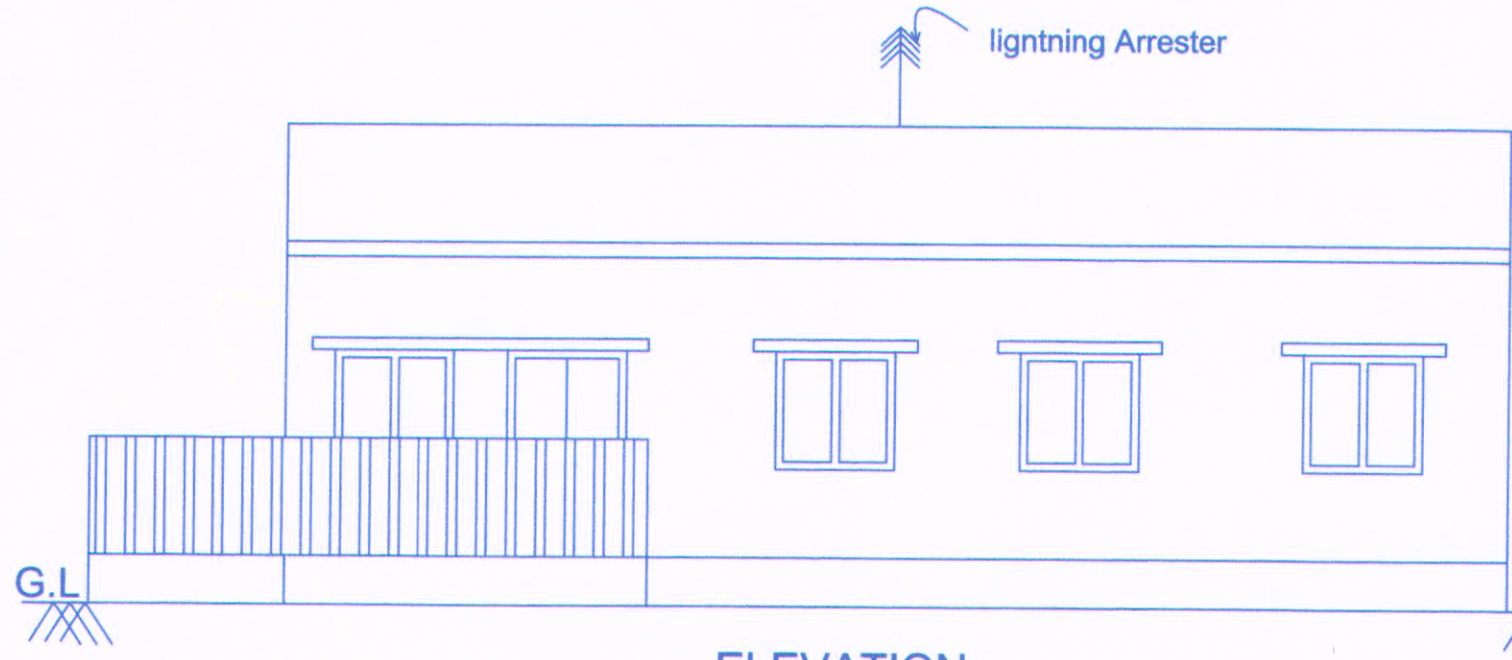


ELEVATION
(BLOCK-2)

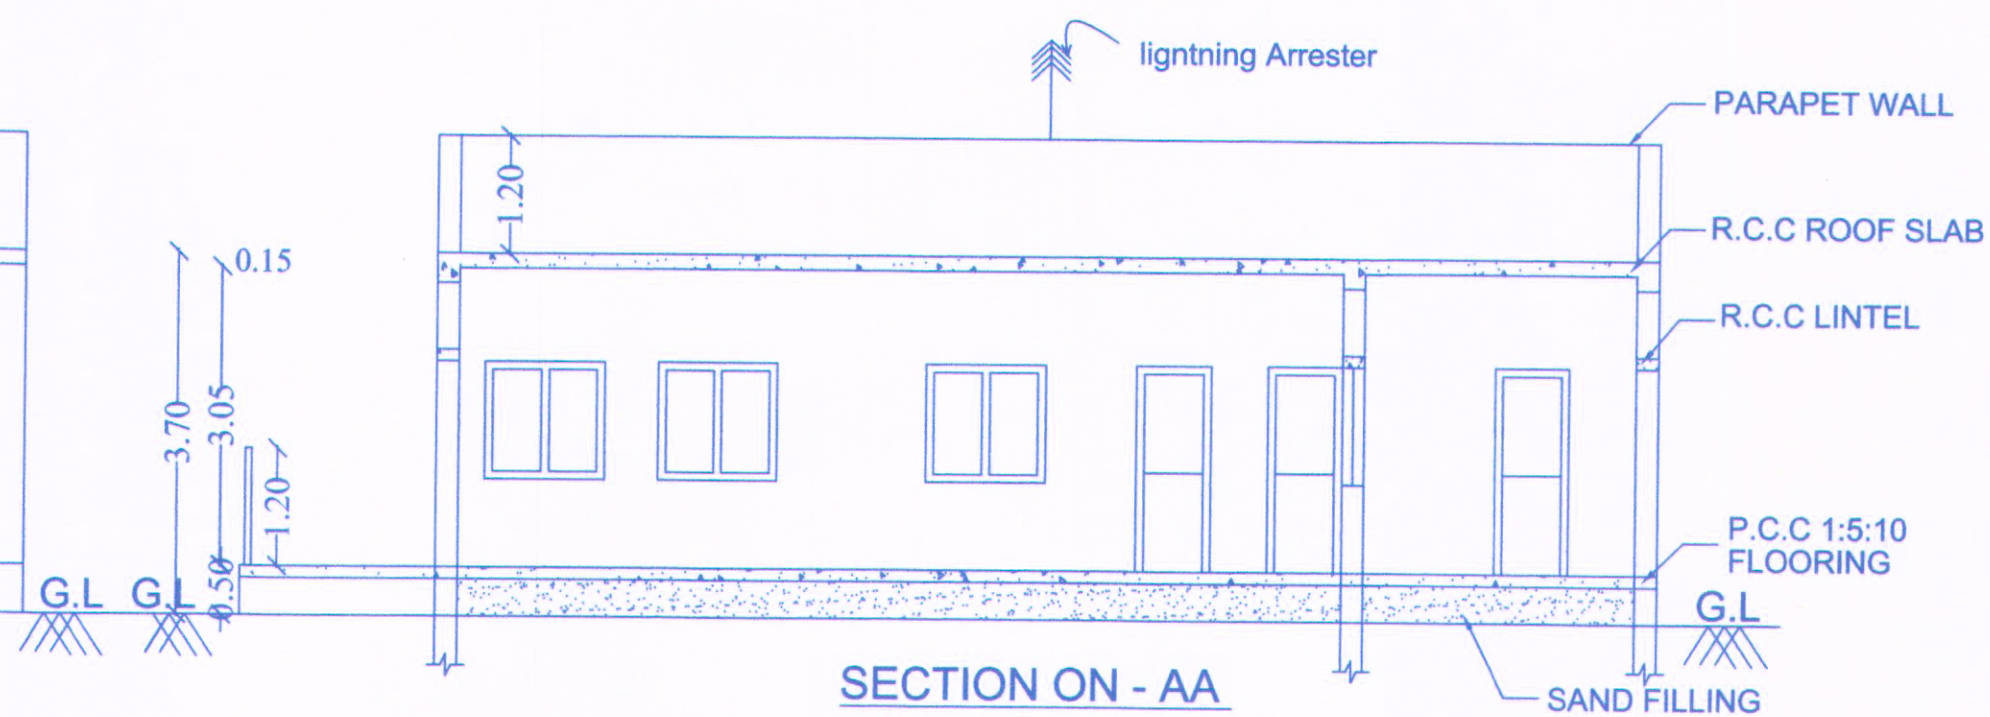

SECTION ON - AA
(BLOCK-2)

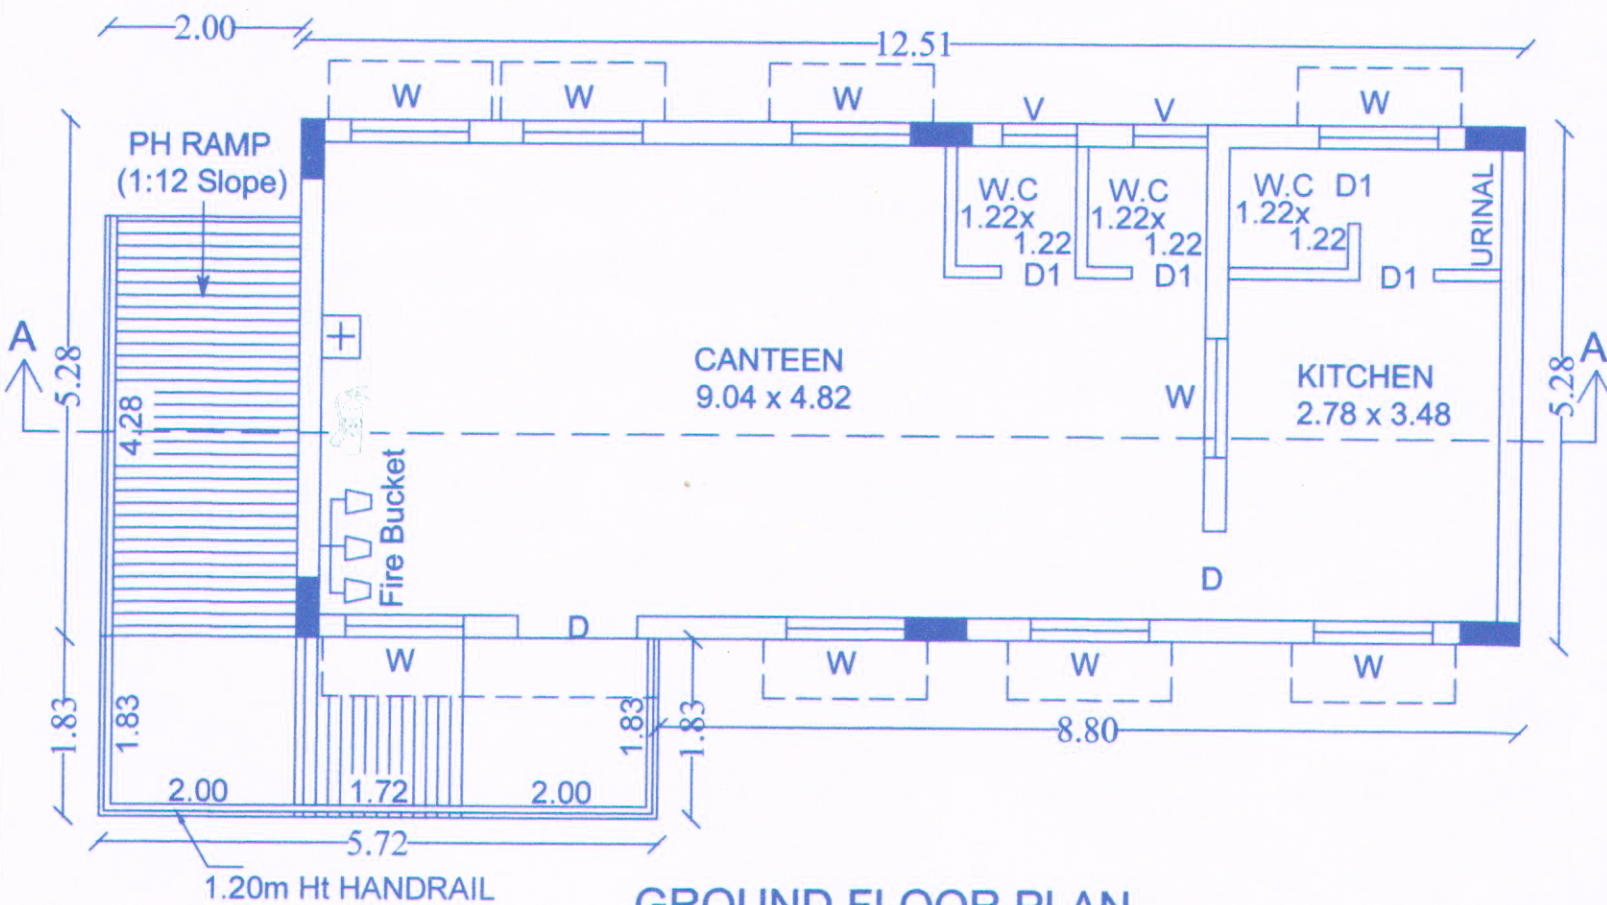

GROUND FLOOR PLAN
(BLOCK-2)

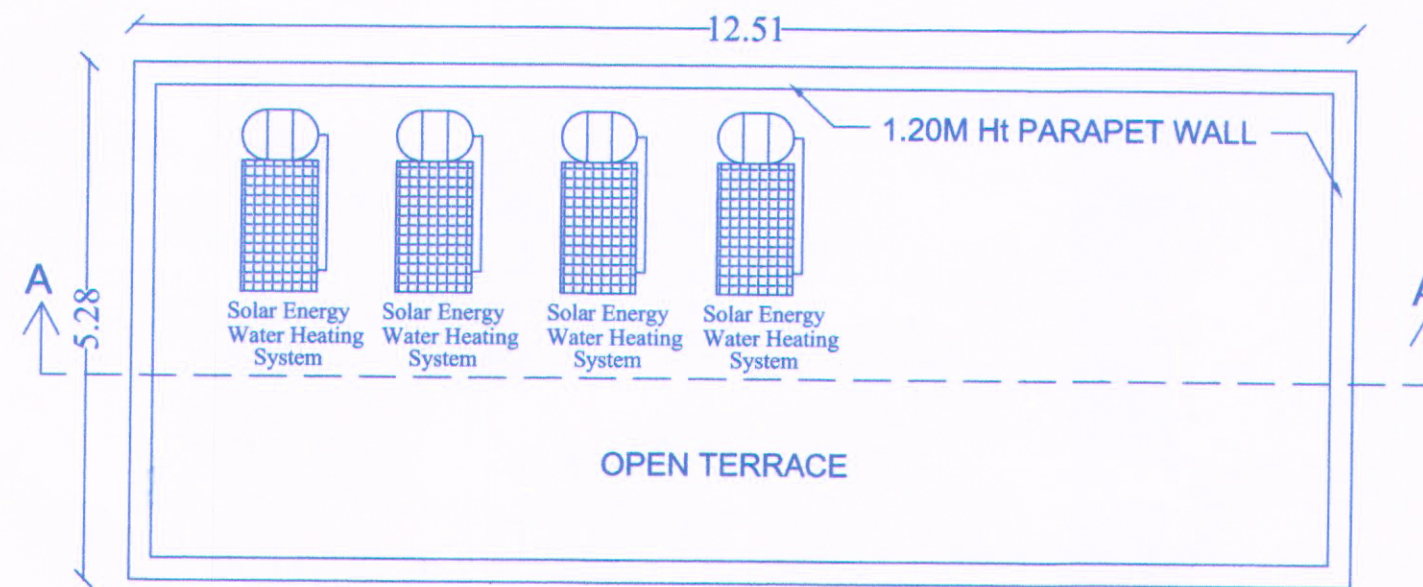

TERRACE FLOOR PLAN
(BLOCK-2)

PLAN SHOWING THE EXISTING AND PROPOSED CONSTRUCTION OF HOSPITAL BUILDING IN S.NO :100/2 AT PALLATHUR VILLAGE , PALLATHUR TOWN PANCHAYAT, KARAUKUDI TALUK, SIVAGANGAI DISTRICT.

(SCALE-1:100)

JOINERY DETAILS

D	DOOR	1.22 x 2.10
D	DOOR	0.76 x 2.10
W	WINDOW	1.20 x 1.20
V	VENTILATOR	0.76 x 0.76

AREA DETAILS

Descriptions	Non FSI (Sq.M)	FSI (Sq.M)	Total Area (Sq.M)
Area of the Ground Floor (Block-02)		66.03	66.03
Total Area		66.03	66.03

NOTE:

ALL DIMENSIONS ARE IN 'M'

In all rooms-Mechanical ventilation to be provided

In all rooms-fire safety measures to be provided

Er.V.XAVIER ANTONY RAJ, M.E.,

DTCP Civil Engineer RE/Gr.1/SVG Region/0016/2019

DTCP Structural Engineer SE/Gr.1/SVG Region/007/2020,

Karaikudi Municipality Regd.Engineer. Gr-1/111/LS/2019/00015,

VEE'X CONSULTANTS

16/2, Valluvar Salai ,

Thilagar Nagar, KARAUKUDI-630 002.

Cell: 94430 92467.

E-mail:vee.x.consultants@gmail.com

STRUCTURAL ENGINEER

For A.M.M. FOUNDATION

Authorised Signatory

R. GURUNATHAN B.Arch.

REGISTERED ARCHITECT GR - I

RA / GR-I / 19 / 03 / 081



22, Padmanabha Nagar 3rd Street

Adyar, Chennai - 600 020

Tel: 044 - 2491 2412

REGISTERED ENGINEER/
ARCHITECT

APPLICANT

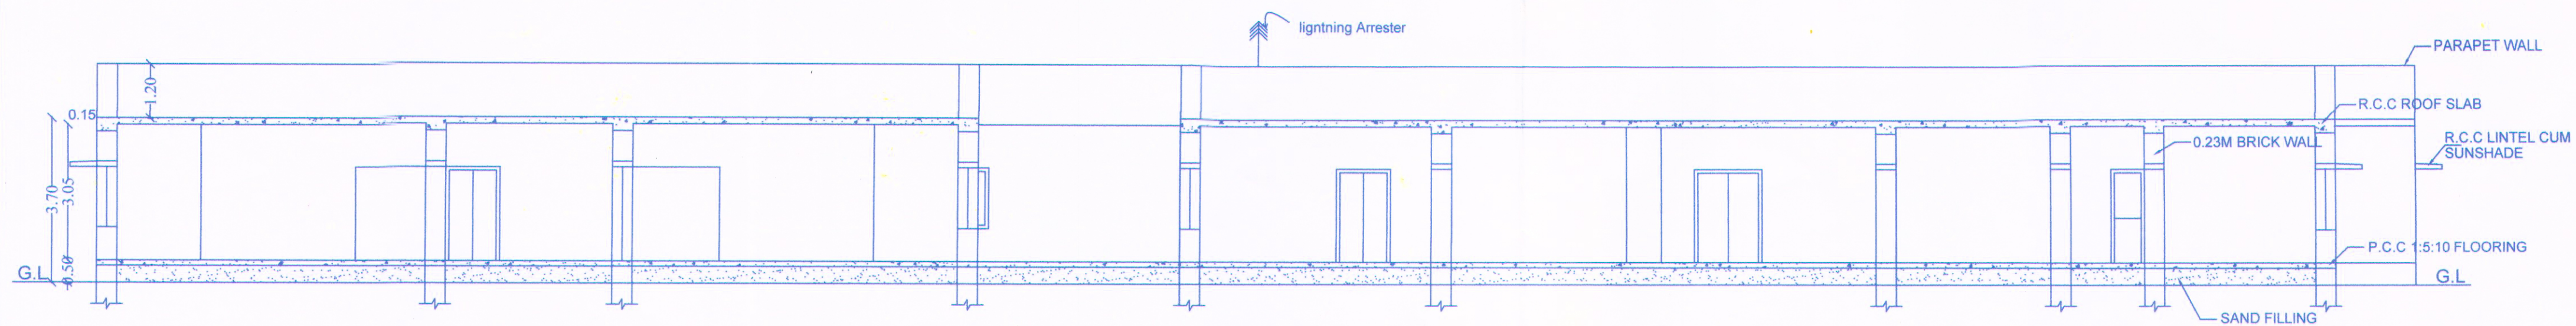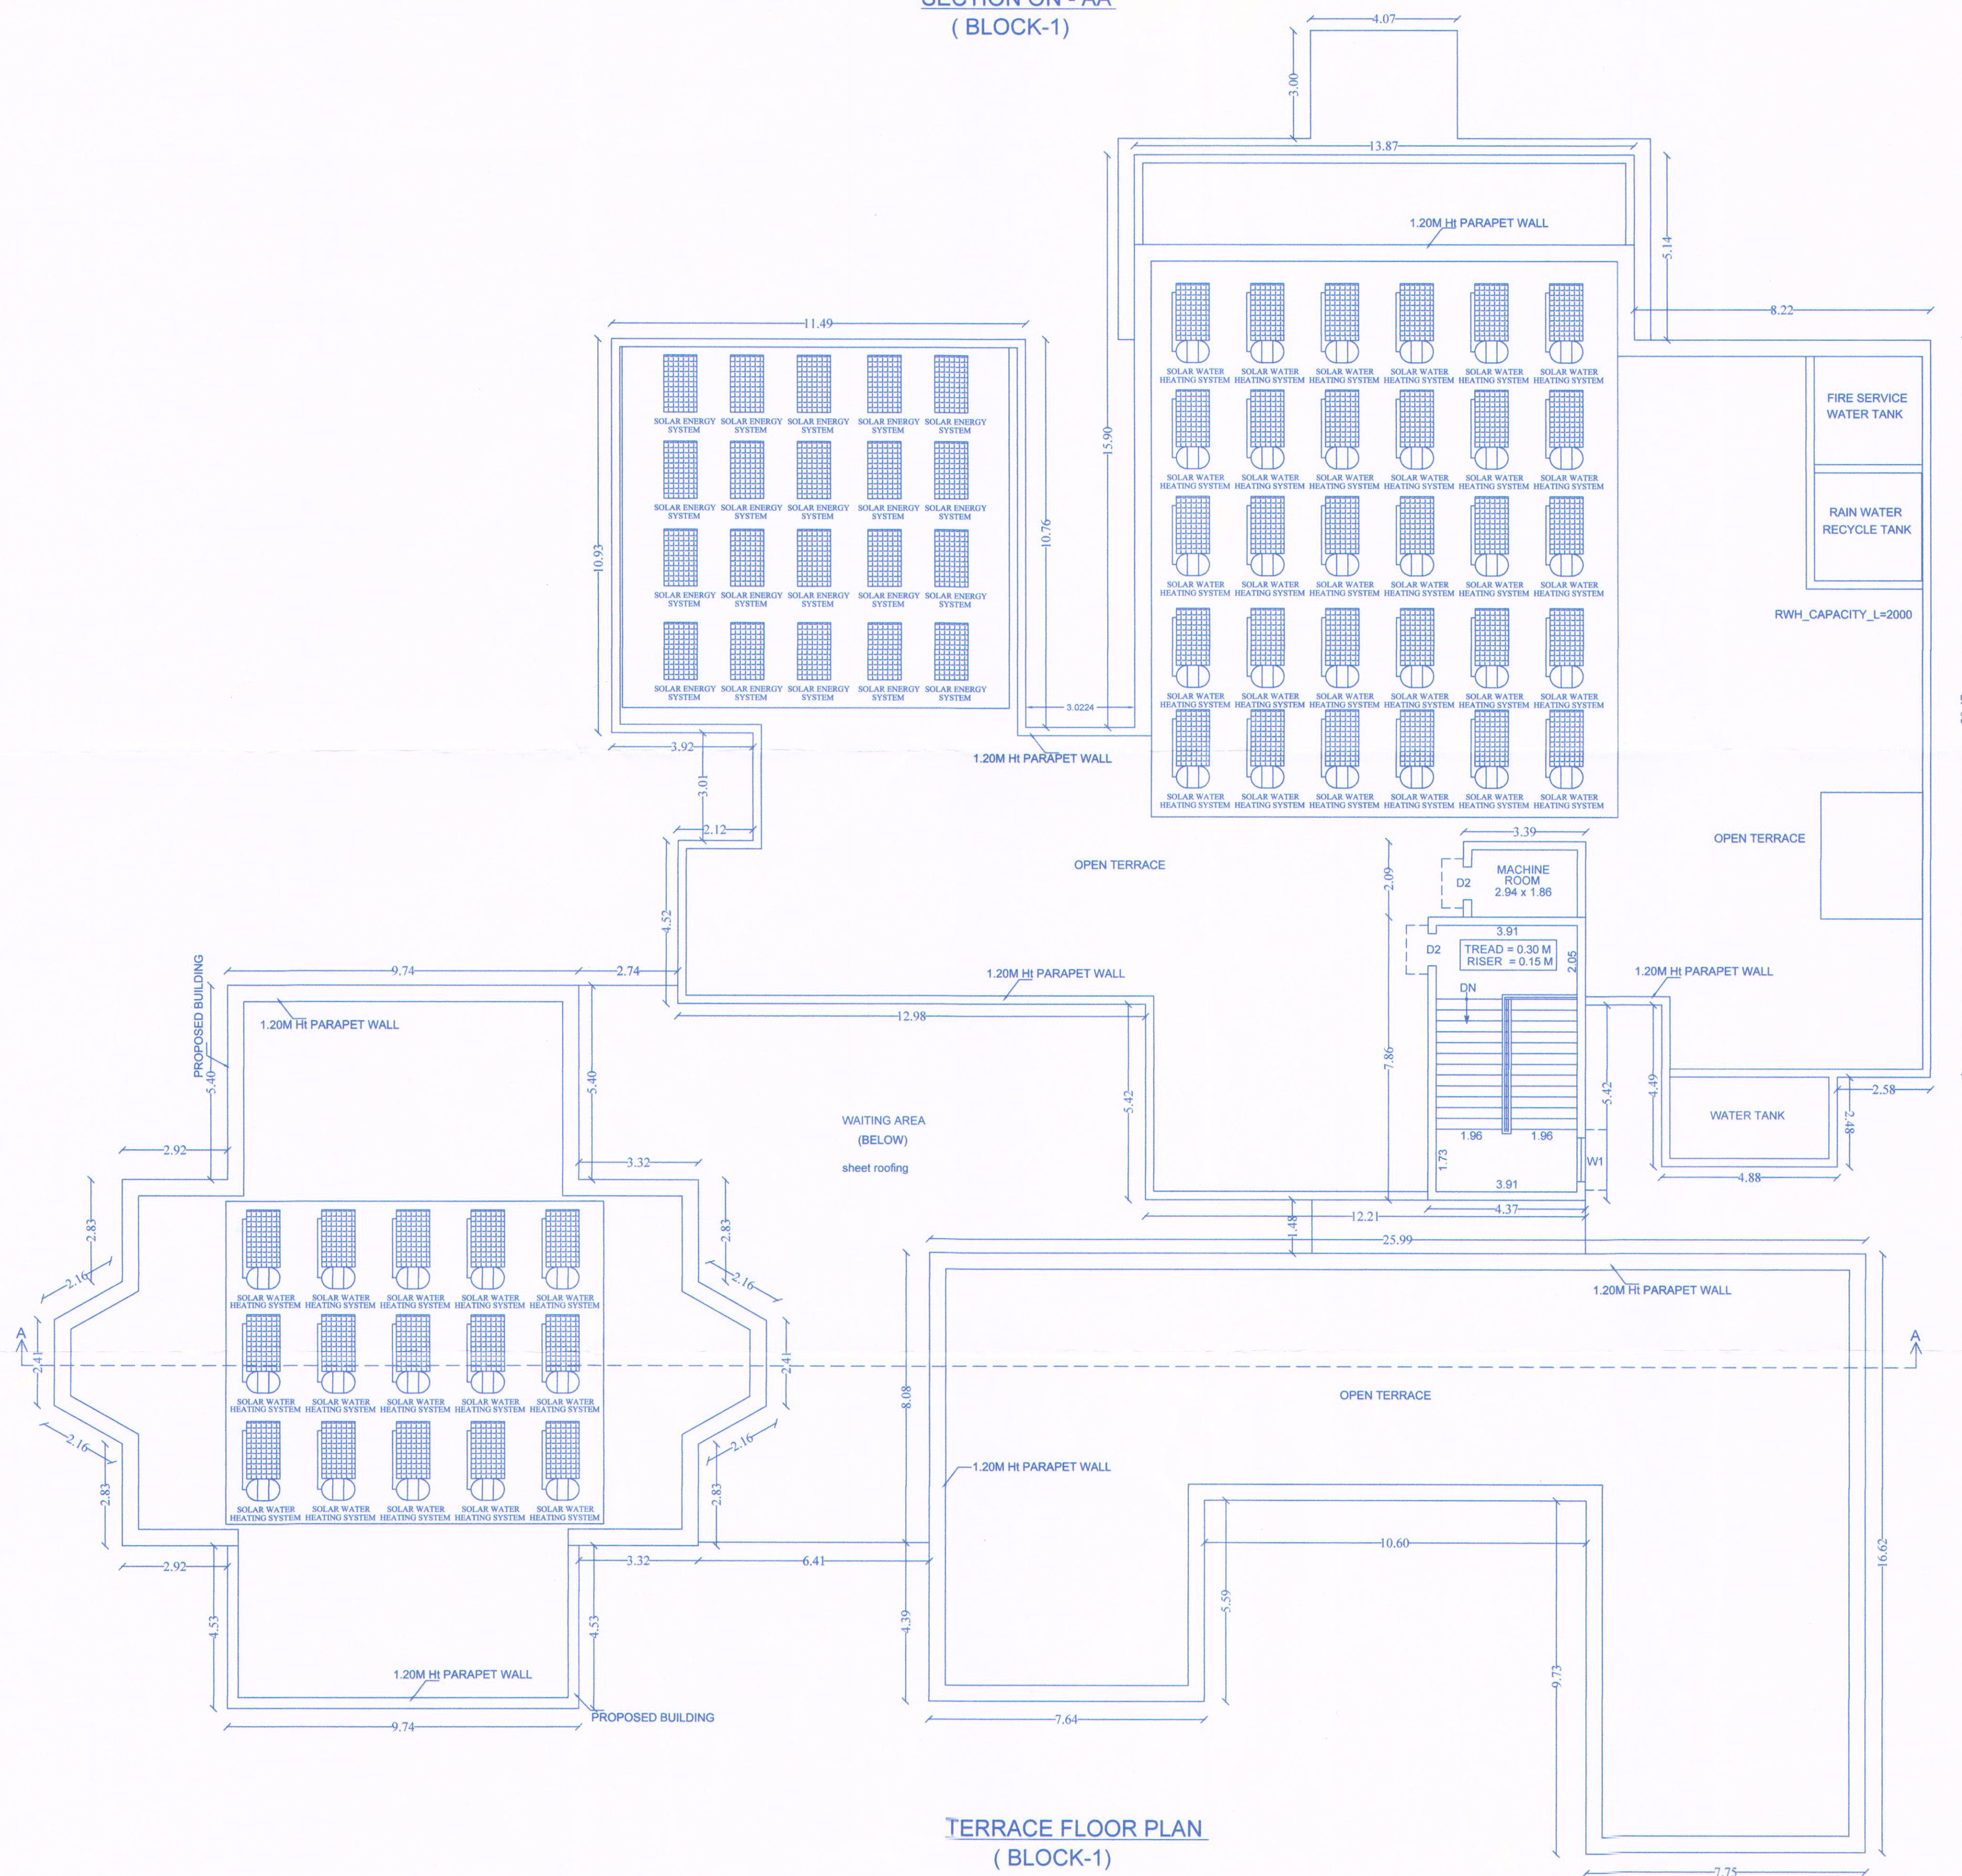SECTION ON - AA
(BLOCK-1)TERRACE FLOOR PLAN
(BLOCK-1)

PLAN SHOWING THE EXISTING AND PROPOSED CONSTRUCTION OF HOSPITAL BUILDING IN S.NO :100/2 AT PALLATHUR VILLAGE , PALLATHUR TOWN PANCHAYAT, KARAUKUDI TALUK, SIVAGANGAI DISTRICT. (SCALE-1:100)

REFERENCE:-

EXISTING BUILDING - ☐
PROPOSED BUILDING - ☐

JOINERY DETAILS

D	DOOR	2.44 x 2.10
D1	DOOR	1.52 x 2.10
D2	DOOR	1.22 x 2.10
D3	DOOR	0.90 x 2.10
D4	DOOR	0.76 x 2.10
W	WINDOW	1.83 x 1.35
W1	WINDOW	1.22 x 1.35
W2	WINDOW	0.90 x 1.35
V	VENTILATOR	0.60 x 0.76

AREA DETAILS (Block -1)

Descriptions	Non FSI (Sq.M)	FSI (Sq.M)	Total Area (Sq.M)
Area of the Ground floor Existing & proposed		1539.83	1539.83
Area of the Terrace floor	41.42		41.42
Total Area	41.42	1539.83	1581.25

NOTE:

ALL DIMENSIONS ARE IN 'M'

In all rooms-Mechanical ventilation to be provided

In all rooms-fire safety measures to be provided

Er.V.XAVIER ANTONY RAJ, M.E.,
DTP Civil Engineer RE/Gr.1/SVG Region/0016/2019
DTP Structural Engineer SE/Gr.1/SVG Region/007/2020,
Karaikudi Municipality Regd Engineer Gr.1/11/15/2019/00015,
VEE'X CONSULTANTS
16/2, Valluvar Salai,
Thilagar Nagar KARAUKUDI-630 002.
Cell: 94430 92467.
mail:vee.x.consultants@gmail.com

STRUCTURAL ENGINEER


For A.M.M. FOUNDATION

Authorised Signatory


APPLICANT

R. GURUNATHAN B.Arch.
REGISTERED ARCHITECT GR - I
RA / GR-I / 19 / 03 / 081
22, Padmanabha Nagar 3rd Street
Adyar, Chennai - 600 020
Tel: 044 - 2491 2412

REGISTERED ENGINEER/ARCHITECT

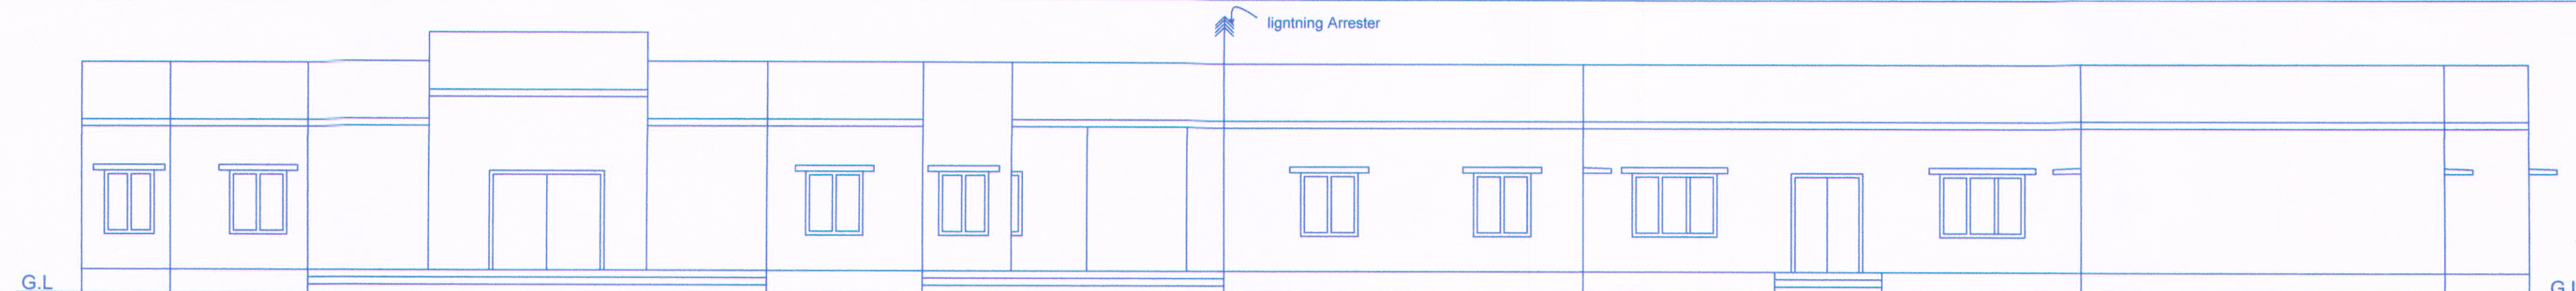

ELEVATION
(BLOCK-1)

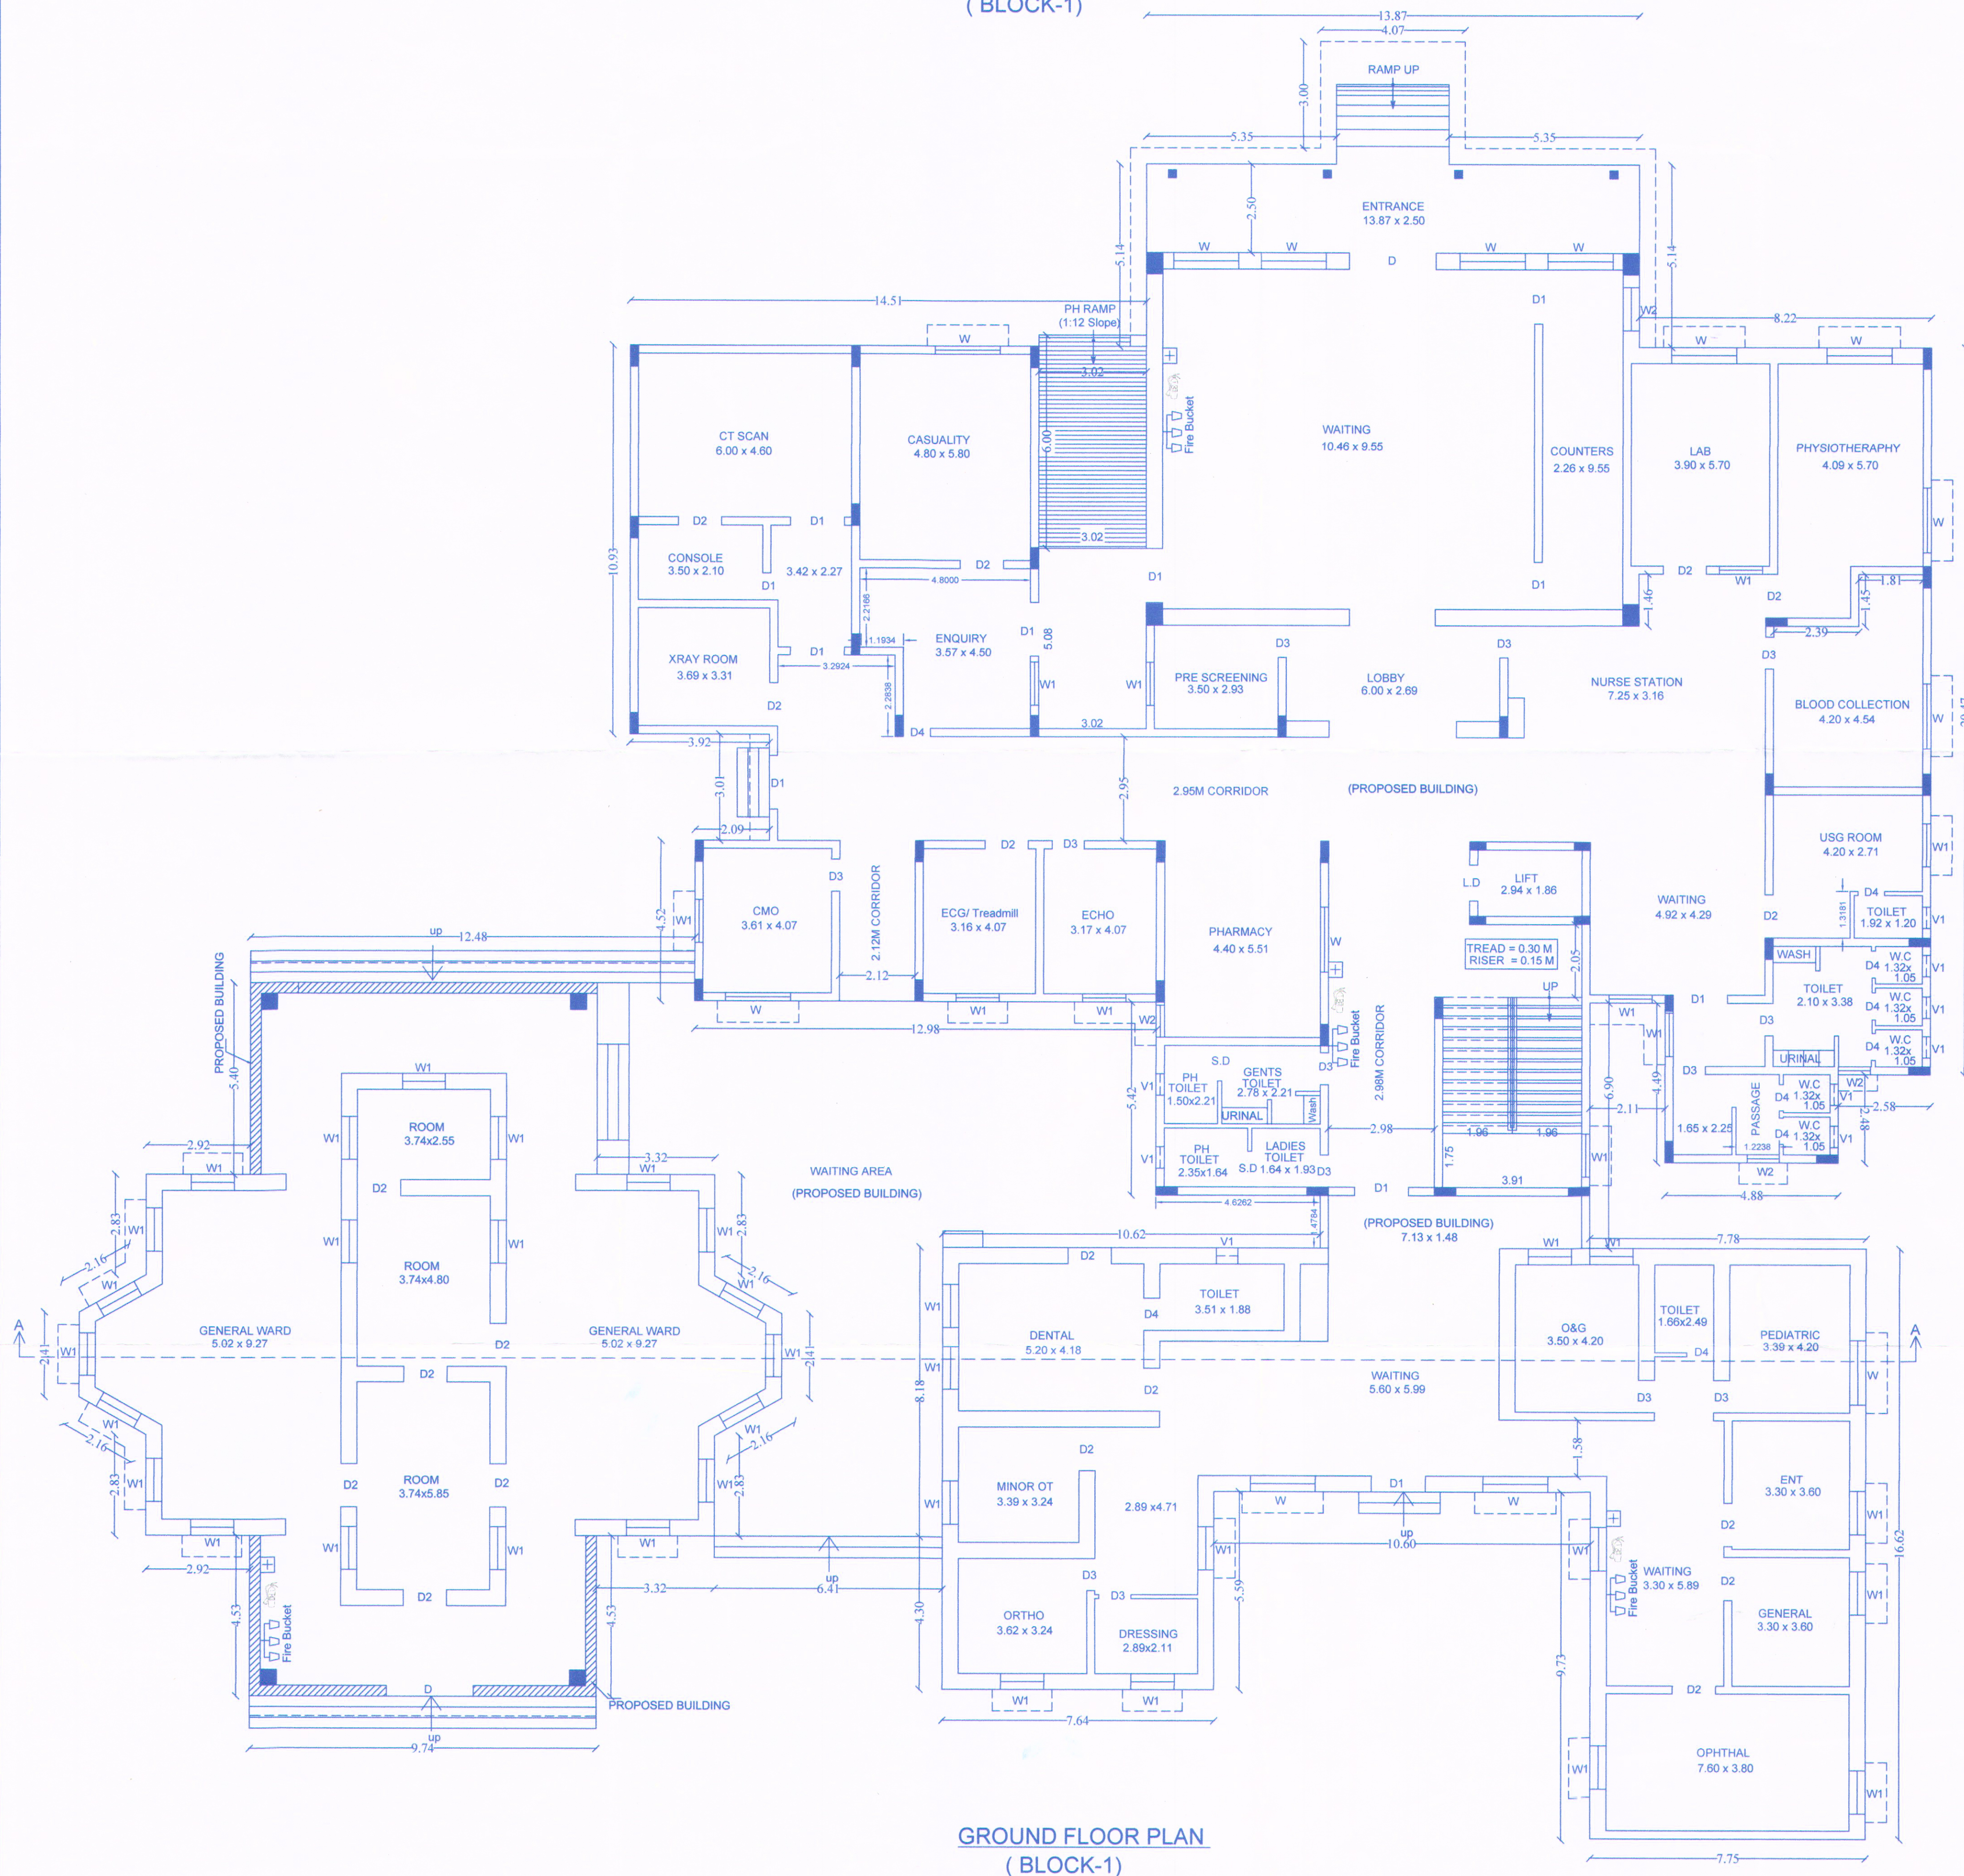

GROUND FLOOR PLAN
(BLOCK-1)

PLAN SHOWING THE EXISTING
AND PROPOSED CONSTRUCTION
OF HOSPITAL BUILDING IN S.NO :100/2
AT PALLATHUR VILLAGE , PALLATHUR
TOWN PANCHAYAT, KARAUKUDI TALUK,
SIVAGANGAI DISTRICT. (SCALE-1:100)

REFERENCE:-

EXISTING BUILDING - 
PROPOSED BUILDING - 

JOINERY DETAILS

D	DOOR	2.44 x 2.10
D1	DOOR	1.52 x 2.10
D2	DOOR	1.22 x 2.10
D3	DOOR	0.90 x 2.10
D4	DOOR	0.76 x 2.10
W	WINDOW	1.83 x 1.35
W1	WINDOW	1.22 x 1.35
W2	WINDOW	0.90 x 1.35
V	VENTILATOR	0.60 x 0.76

AREA DETAILS (Block -1)

Descriptions	Non FSI (Sq.M)	FSI (Sq.M)	Total Area (Sq.M)
Area of the Ground floor Existing & proposed		1539.83	1539.83
Area of the Terrace floor	41.42		41.42
Total Area	41.42	1539.83	1581.25

NOTE:

ALL DIMENSIONS ARE IN 'M'

In all rooms-Mechanical ventilation to be provided
In all rooms-fire safety measures to be provided

Er.V. XAVIER ANTONY RAJ, M.E.,
DTP Civil Engineer RE/Gr.1/SVG Region/0016/2019
DTP Structural Engineer SE/Gr.1/SVG Region/007/20
Karaikudi Municipality Regd. Engineer Gr.1/111/LS/2019/000
VEE'X CONSULTANTS
18/2, Valluvar Salai,
Thilagar Nagar, KARAUKUDI-630 002.
Cell: 94430 92467
E.mail:vee.x.consultants@gmail.com

STRUCTURAL ENGINEER

For A.M.M. FOUNDATION

Authorised Signatory

APPLICANT



R. GURUNATHAN B.Arch.
REGISTERED ARCHITECT GR - I
RA/ GR-1 / 19 / 03 / 081
22, Padmanabha Nagar 3rd Street
Adyar, Chennai - 600 020
Tel: 044 - 2491 2412

REGISTERED ENGINEER/ARCHITECT

SITE PLAN SHOWING THE EXISTING AND PROPOSED CONSTRUCTION OF HOSPITAL BUILDING IN S.NO :100/2 AT PALLATHUR VILLAGE , PALLATHUR TOWN PANCHAYAT, KARAIKUDI TALUK, SIVAGANGAI DISTRICT.

(SCALE - 1:400)

REFERENCE :-

SITE BOUNDARY	-	
EXISTING ROAD	-	
EXISTING BUILDING	-	
PROPOSED BUILDING	-	
DRIVE WAY	-	
O.S.R	-	
DEMOLISHED	-	
WATER BODY	-	

AREA DETAILS

SITE EXTENT - 43700.00SQ.M

DESCRIPTION	Non FSI SQ.M	FSI SQ.M	Total Area SQ.M
Area of the Ground Floor (Block-01) Existing & Proposed		1539.83	1539.83
Area of the Proposed Terrace Floor (Block-01)	41.42		41.42
Area of the Ground Floor (Block-02)		66.03	66.03
Area of the Ground Floor (Block-3)		222.49	222.49
Area of the Ground Floor (Block-4)		100.62	100.62
Area of the Ground Floor (Block-5)		149.43	149.43
Area of the First Floor (Block-5)		149.43	149.43
Area of the Head Room (Block-5)	12.74		12.74
Area of the Ground Floor (Block-06)		241.83	241.83
TOTAL AREA	54.16	2469.66	2523.82

FLOOR SPACE INDEX = $\frac{2469.66}{43700.00} = 0.056$

O.S.R AREA REQUIRED - 4370.00 (10.00 %)

O.S.R AREA PROVIDED - 4382.30 (10.02 %)

CAR PARKING REQUIRED - 23 Nos

CAR PARKING PROVIDED - 36 Nos

TWO WHEELER PARKING REQUIRED - 23 Nos

TWO WHEELER PARKING PROVIDED - 30 Nos

NOTE:

ALL DIMENSIONS ARE IN 'M'

ONLINE APPLICATION NUMBER -SWP/BPA/012126/2023

BP/DTCP (SIVAGANGAI DISTRICT) NO:16/2023

OFFICE USE

Er.V.XAVIER ANTONY RAJ, M.E.,
DTC Civil Engineer RE/Gr.1/SVG Region/0016/2019
DTC Structural Engineer SE/Gr.1/SVG Region/007/2020
Karaikudi Municipality Regd. Engineer, Gr.1/L1/L1/L1/2019/00015,
VEE'X CONSULTANTS
16/2, Valluvar Salai,
Thilagar Nagar, KARAIKUDI-630 002.
Cell: 94430 92467.
E-mail:vee.x.consultants@gmail.com
STRUCTURAL ENGINEER


For A.M.M. FOUNDATION

Authorised Signatory

APPLICANT

R. GURUNATHAN B.Arch.
REGISTERED ARCHITECT GR - I
RA/GR-1/19/03/081
22, Padmanabha Nagar 3rd Street
Adyar, Chennai - 600 020
Tel: 044 - 2491 2412

REGISTERED ENGINEER/ARCHITECT

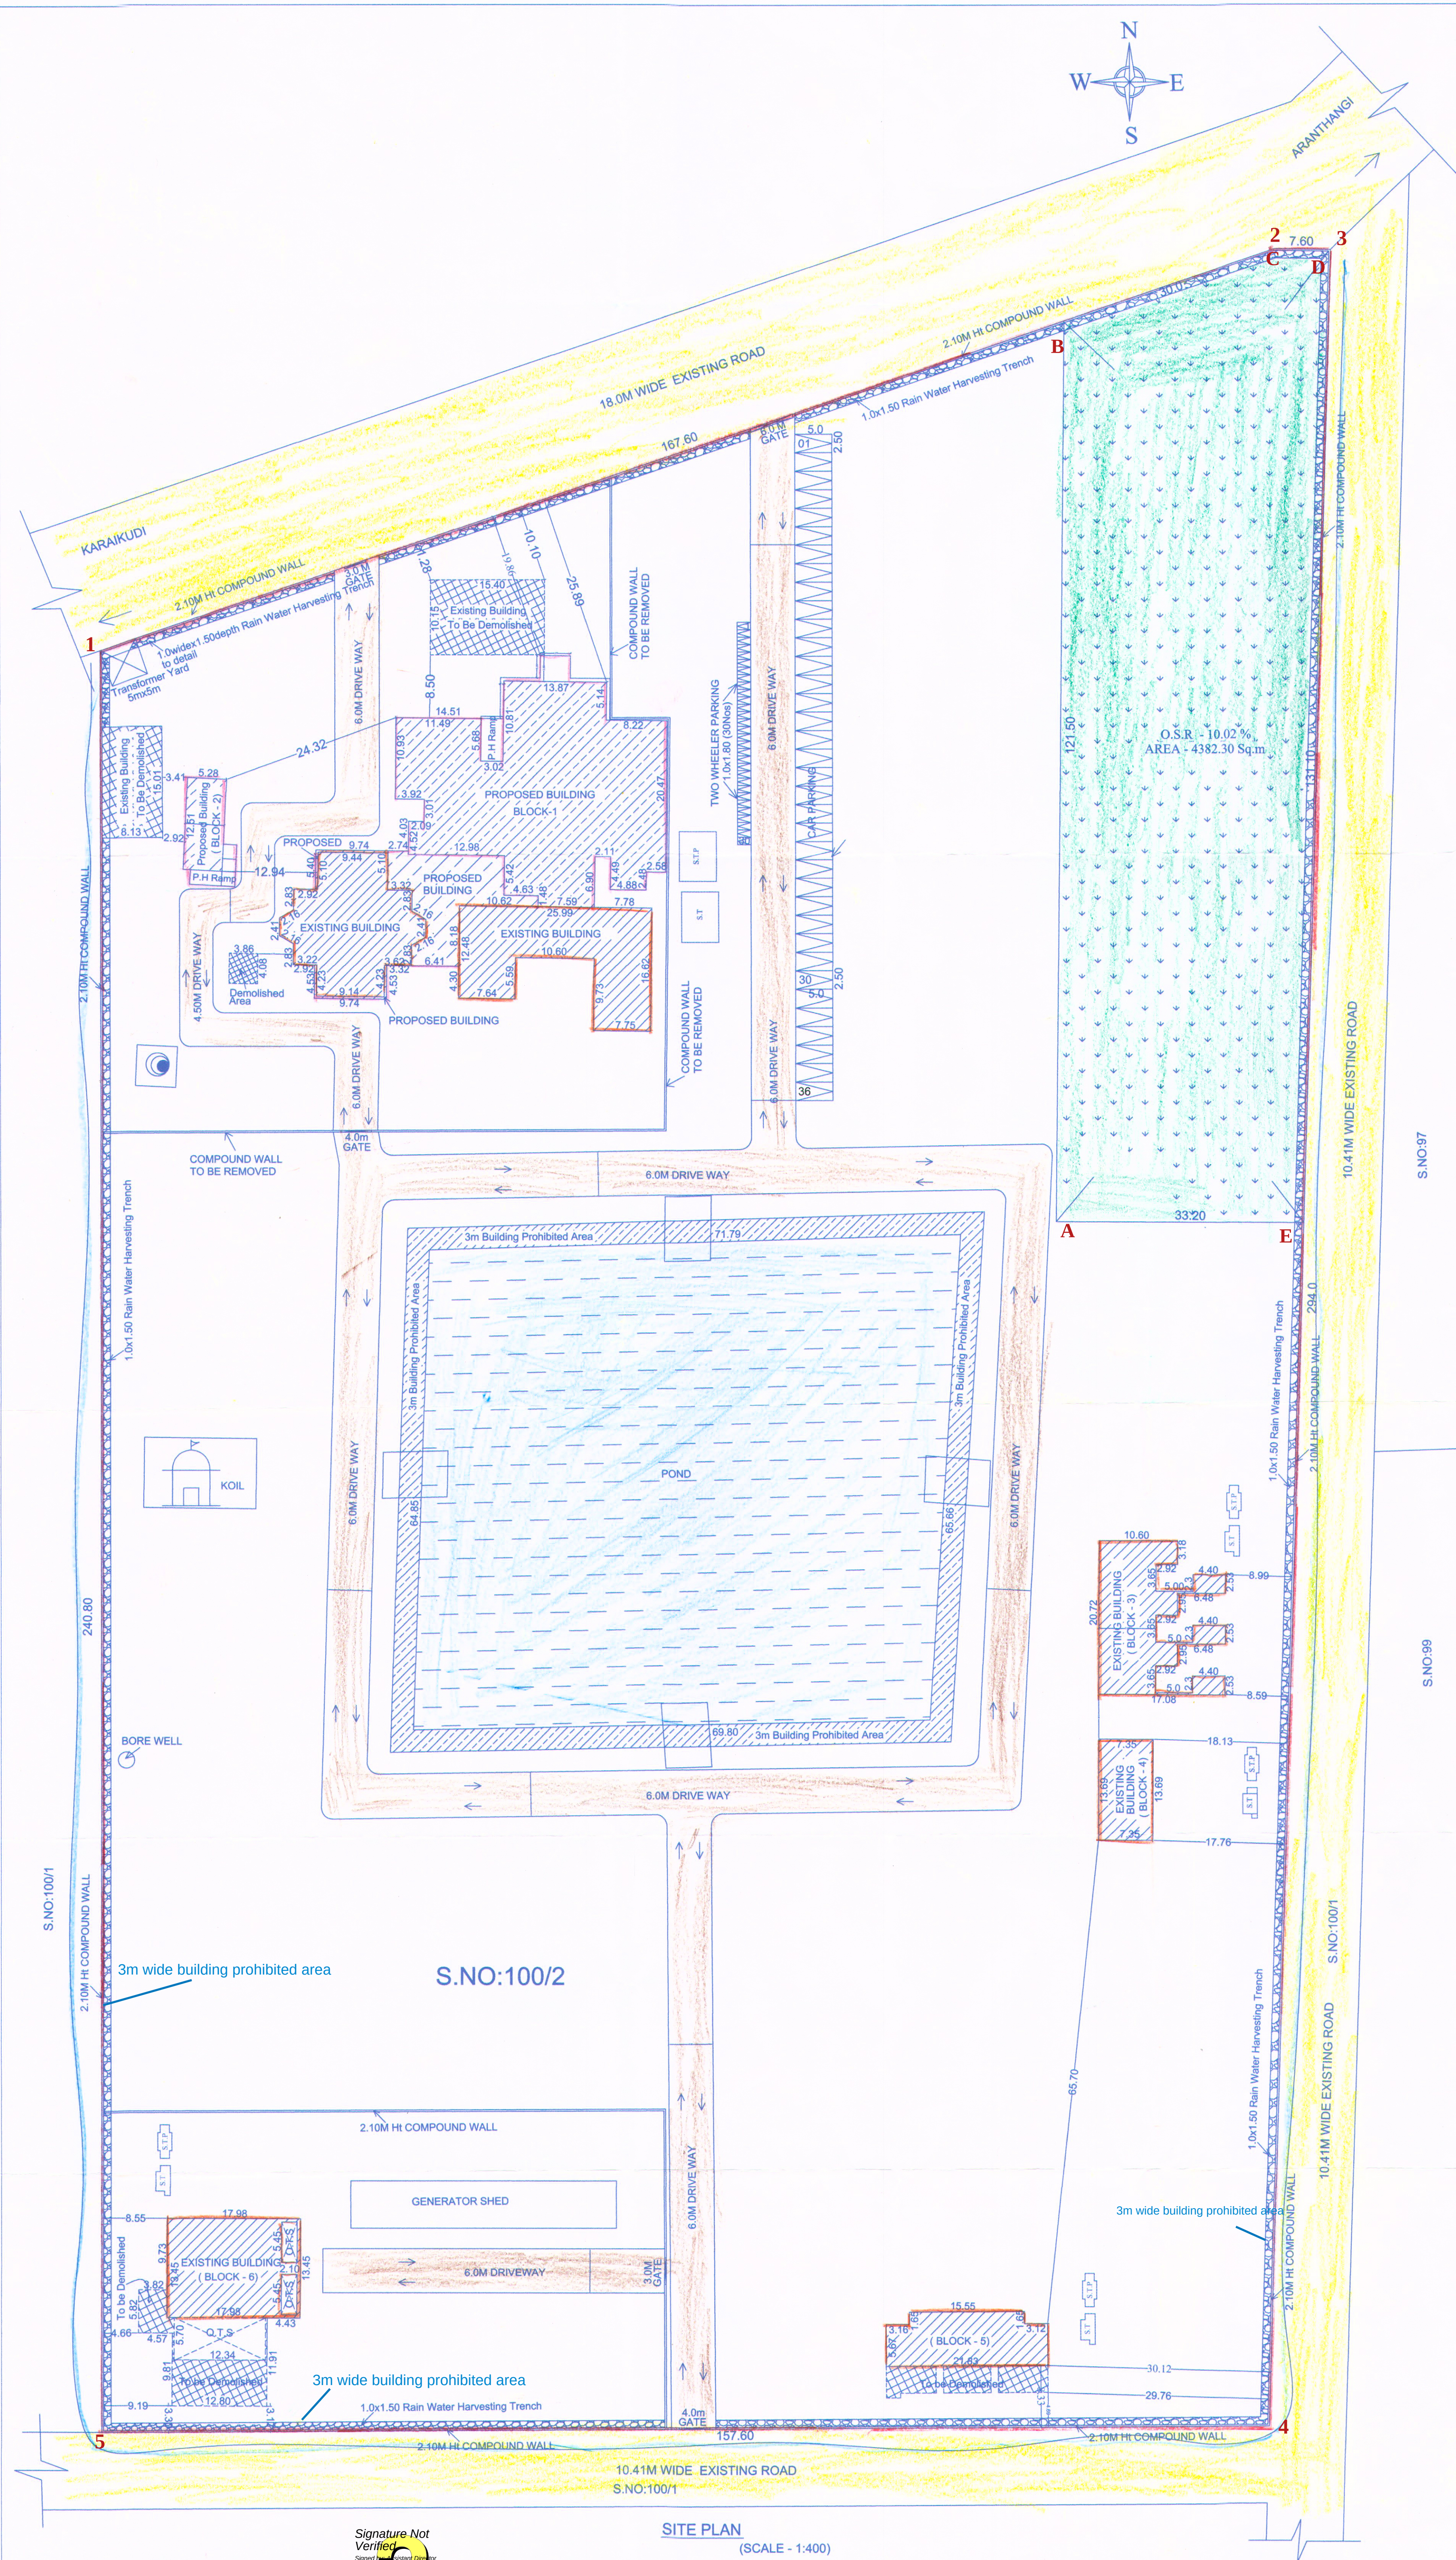SITE PLAN
(SCALE - 1:400)

Signature Not
Verified
SIGNED BY: Assistant Director
Location: Sivagangai District
Date: 2023.12.14 09:46:00