



Your trusted partner for buying, selling, and managing property,
ensuring hassle-free service with 100% transparency.

3/350/2 Mettukuppam,
OMR Thoraipakkam,
Chennai, India


hello@verified.realestate

+91 9996 12 9996


www.verified.realestate

Official Property Record



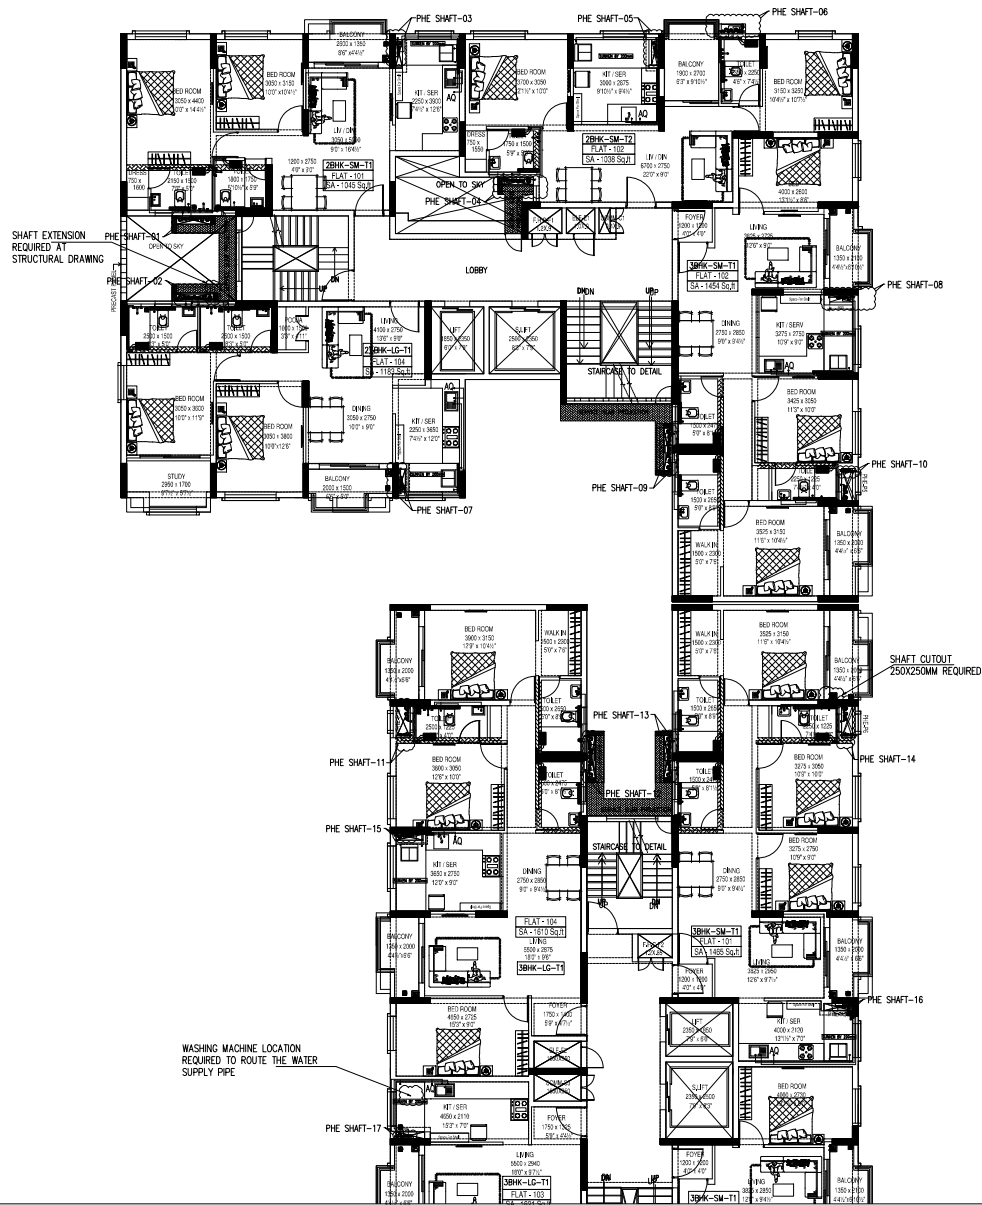


PART A

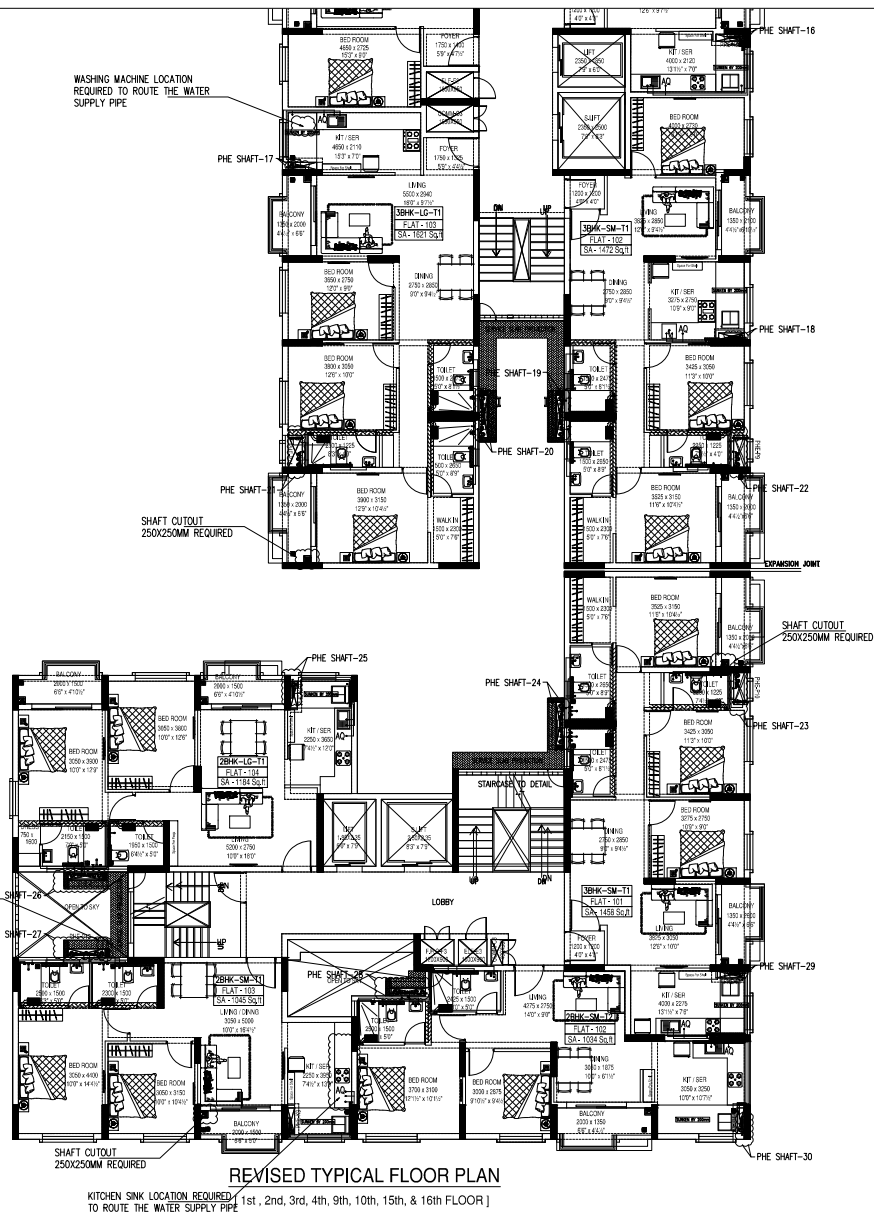

PART B

PLAN – LAYOUT OF WATER SUPPLY PIPE ARRANGEMENTS AT TYPICAL FLOOR PLAN 1st,2nd,3rd,4th,9th,10th,15th & 16th FLOOR

SYMBOL	DESCRIPTION OF SYMBOL	NOTES:	MATERIAL TO BE USED:	ABBREVIATIONS:-
	WALLHUNG EUROPEAN WATER CLOSET WITH DUAL FLUSHING CISTERN (EXPOSED TANK)	01 – USE CPVC SDR 13.5 & 11 GRADE FOR INTERNAL COLD & HOT WATER SUPPLY PIPES RESPECTIVELY.	● WATER SUPPLY PIPES (INTERNAL) – CPVC SDR 13.5 FOR COLD WATER	HFBC – HEALTH FAUCET BROCK
	RECTANGULAR WASHBASIN	02 – AVOID USING GI EXTENSION NIPPLES FOR CONNECTING WITH C.P FITTINGS.	● WATER SUPPLY PIPES (SHAFT & TERRACE) – CPVC SDR 11 FOR HOT WATER	FC – FLUSHING CISTERN
	SINGLE BOWL SINK WITH DRAIN BOARD	03 – DOMESTIC WATER WILL BE USED FOR HEALTH FAUCETS, WASHBASIN, SINK, WASHING MACHINE & SHOWER	● WATER SUPPLY PIPES (BURIED) – UPVC SCH 80	WB – WASHBASIN
	WASHING MACHINE	04 – TREATED WATER WILL BE USED FOR FLUSHING CISTERN.		NW – WASHING MACHINE
	SHOWER ARM & ROSE	05 – METRO WATER WILL BE USED FOR DRINKING & COOKING.		SH – SHOWER
	DR – DIVERTOR AT 4'-0" ABOVE FFL	06 – HOT WATER WILL BE USED FOR SHOWER ONLY.		CSC – CONCEALED STOPOCK
	WM – WALLMIXER AT 3'-0" ABOVE FFL	07 – PROVIDE CONTROL VALVE ON ALL BRANCH RISER/DROP PIPES AT ACCESSIBLE LOCATION.		AG – AQUAGUARD
	OWS – OVERHEAD SHOWER AT 6'-9" ABOVE FFL	08 – ALL WATER SUPPLY PIPES ARE TO BE HYDRAULICALLY TESTED TO 7kg/SQ.Cm OR 1.5 TIMES OF THE WORKING PRESSURE, WHICH EVER IS HIGHER TO MINIMUM OF 60 MINUTES.		
SYMBOL	DESCRIPTION OF SYMBOL	NOTES:	LEVELS FOR SANITARY FITTINGS:	
	HWS – HOT WATER SUPPLY PIPE	09 – BEFORE PROCEEDING WITH INTERNAL WATER SUPPLY WORK, CONTRACTOR TO VERIFY THE INLET & OUTLET OF THE SELECTED SANITARY WARES & C.P.FITTINGS. NO WORK ARE TO BE CARRIED OUT WITHOUT HAVING THE SAMPLE OF ALL – THE TYPE OF THE SAME AT SITE.	FC – FLUSHING CISTERN (CONCEALED)	
	TES – TREATED EFFLUENT SUPPLY PIPE	10 – ALL PIPES WILL BE SUPPORTED IN WALL.	AV/HFBC – ANGLE VALVE STOP COCK AT 1'-8" ABOVE FFL TO CONNECT HEALTH FAUCET BROCK	
	DWS (P) – DOMESTIC WATER SUPPLY PIPE (PRESSURIZED MAIN)	11 – ALL WATER SUPPLY PIPES ARE TO BE HYDRAULICALLY TESTED TO 7kg/SQ.Cm OR 1.5 TIMES OF THE WORKING PRESSURE, WHICH EVER IS HIGHER TO MINIMUM OF 60 MINUTES.	AV/WB – ANGLE VALVE STOP COCK AT 1'-8" ABOVE FFL TO CONNECT WASH BASIN	
	BV – BALL VALVE		CSC – CONCEALED STOP COCK AT 5'-6" ABOVE FFL	

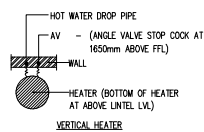

GENERAL NOTES

KEY PLAN

PART A

PART B

RO NO.	ISSUED FOR APPROVAL	26.06.2024	SADIQUE
NO.	REVISION/ISSUE	DATE	DRAWN

PROJECT TITLE:

Proposed Residential Building
"S&P NEW HAVEN RIBBON WALK"
For M/S. S&P FOUNDATIONS,
At Mambakkam Wing 2 & 7, Chennai.

ARCHITECT:

ANBU & FAIZAL
Architects and Interior Designers
OFF-3, II FLOOR "AMAR SINDUR"
43, PANTHEON ROAD,
EGMORE, CHENNAI - 600 008
Phone - 044 - 2855 4262, 044 - 2841 0888.
E-mail -> anbu.faizal@gmail.com
Web -> anbuandfaizal.com




Balu & Associates
Public Health Engineers & Fire Fighting Consultants
No.10/5, Second Floor, Mahalakshmi Street,
Tambaram East, Chennai-600 059, Telfax : Ph : 044-2239 2178
E-mail : engineering@baluassociates.com &
balu_associates@yahoo.co.in
Website : www.baluassociates.com

DRAWING TITLE:


PLAN - LAYOUT OF WATER SUPPLY PIPE
ARRANGEMENTS AT TYPICAL FLOOR PLAN
1st,2nd,3rd,4th,9th,10th,15th & 16th FLOOR

PROJECT NO : 0000/000	SHEET NO: BA/S&P-NHRW/PHE/001
DRAWN BY : SADIQUE	
CHECKED BY : SARATH	NORTH POINT: North W E S
SCALE : A1 = 1:80 A3 = 1:160	
DATE : 26.06.2024	

WING 2

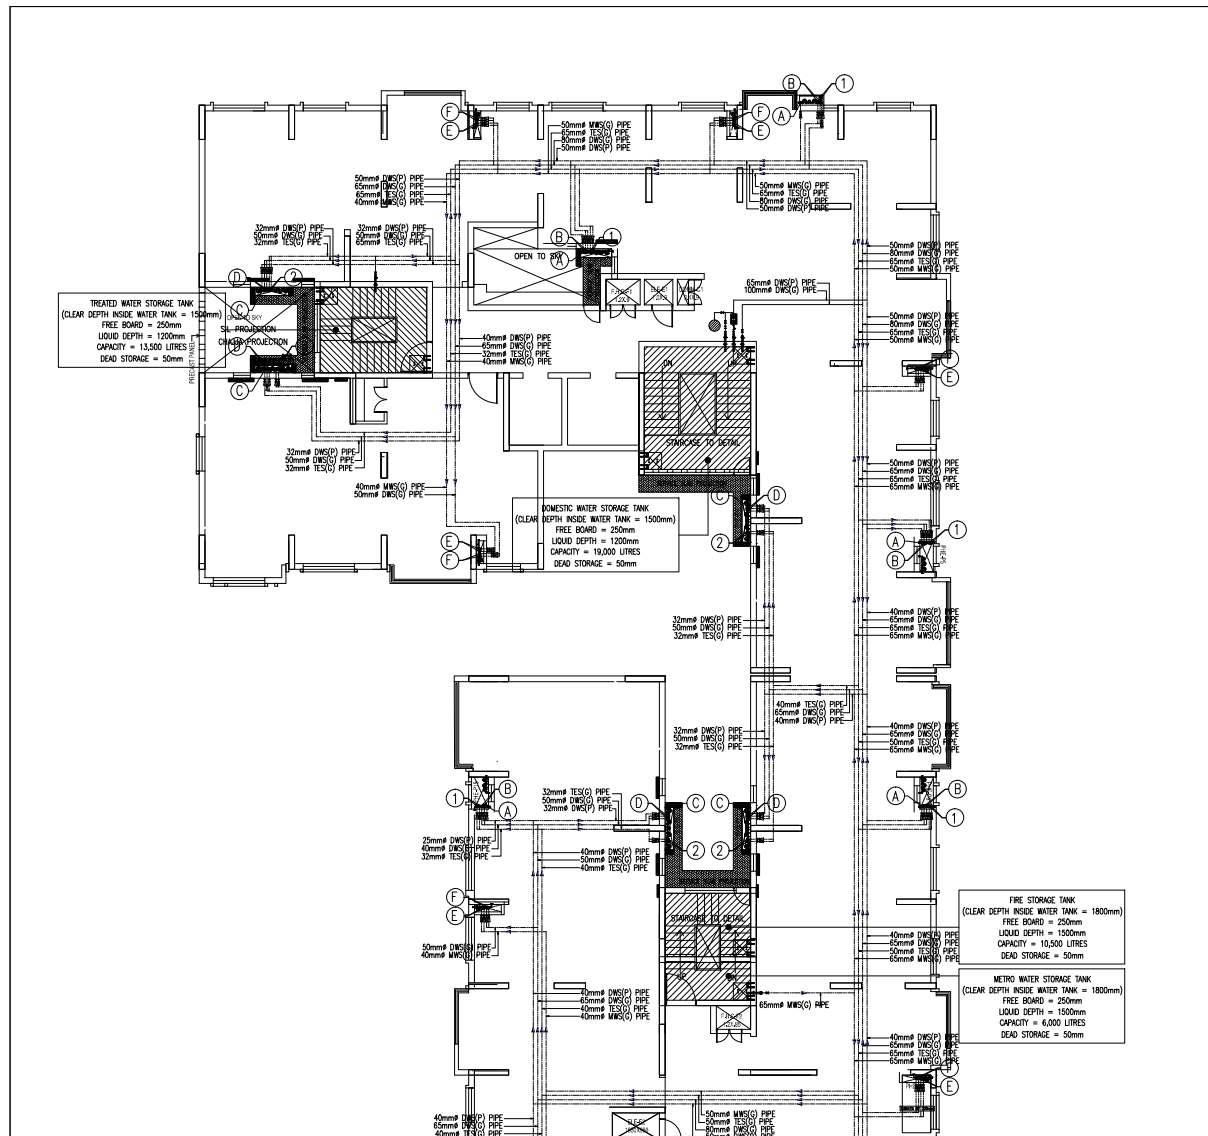

PART A

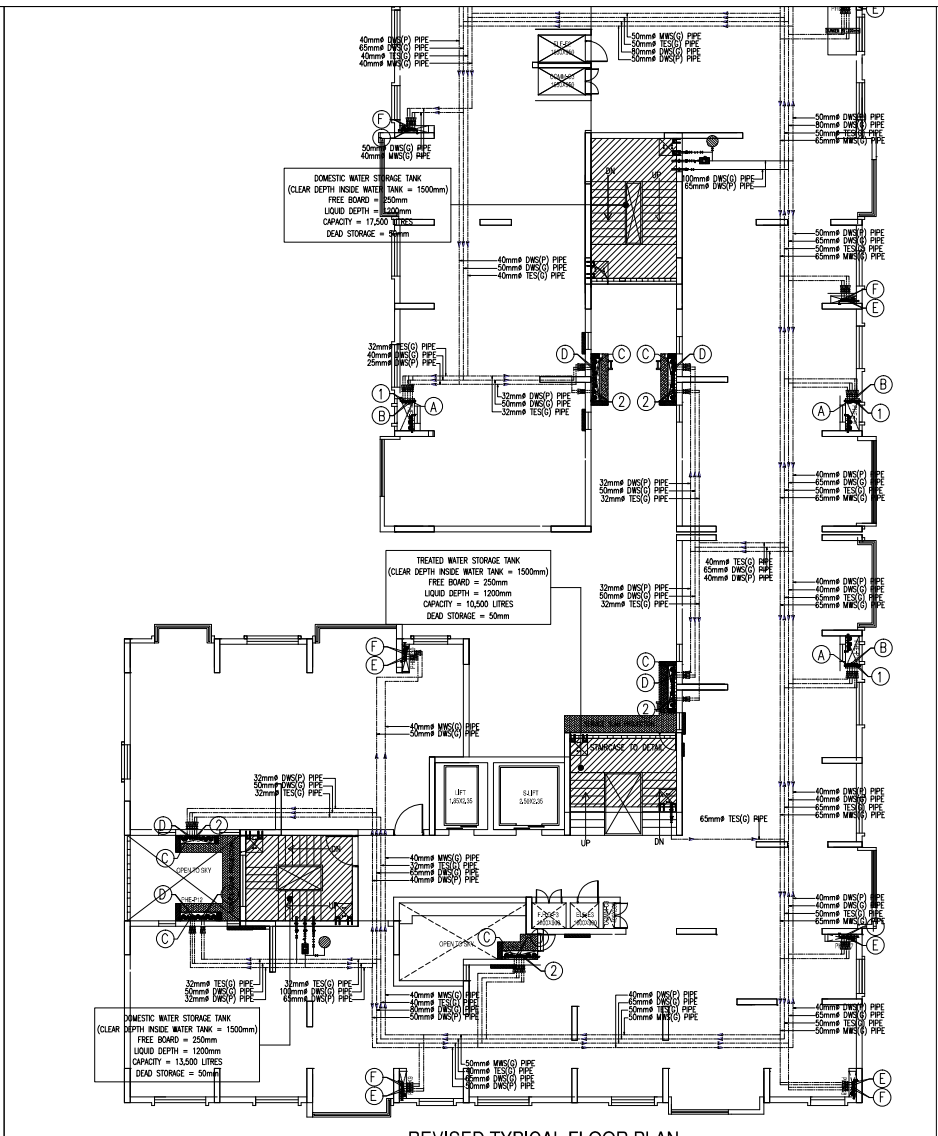


PART B

PLAN - LOCATION OF DOMESTIC WATER & TREATED EFFLUENT TANK AND TERRACE PIPING

DETAILS OF WATER SUPPLY DROP PIPES											
FLOORS	DOMESTIC WATER SUPPLY PIPE (PRESSURISED MAIN & GRAVITY) & TREATED EFFLUENT WATER SUPPLY PIPE (BY GRAVITY)										
TERRACE FLOOR	MWS(G)	MWS(G)	TES(G)	TES(G)	DWS(G)	DWS(G)	DWS(P)	DWS(P)	DWS(P)	DWS(P)	DWS(P)
SIXTEENTH FLOOR	25mm	40mm	40mm	32mm	50mm	50mm	32mm	32mm	40mm	40mm	40mm
FIFTEENTH FLOOR	25mm	40mm	40mm	32mm	50mm	50mm	32mm	32mm	40mm	40mm	40mm
FOURTEENTH FLOOR	20mm	40mm	40mm	25mm	50mm	50mm	32mm	32mm	40mm	40mm	40mm
THIRTEENTH FLOOR	40mm	40mm	50mm	50mm	25mm	32mm	32mm	40mm	40mm	40mm	40mm
TWELFTH FLOOR	40mm	40mm	50mm	50mm	25mm	32mm	32mm	40mm	40mm	40mm	40mm
ELEVENTH FLOOR	32mm	40mm	40mm	50mm	25mm	32mm	25mm	40mm	40mm	40mm	40mm
TENTH FLOOR	32mm	40mm	40mm	50mm	20mm	32mm	25mm	40mm	40mm	40mm	40mm
NINTH FLOOR	25mm	40mm	40mm	32mm	20mm	32mm	20mm	40mm	40mm	40mm	40mm
DROP PIPES	① DROP	② DROP	③ DROP	④ DROP	⑤ DROP	⑥ DROP	⑦ DROP	⑧ DROP	⑨ DROP	⑩ DROP	⑪ DROP
	SINGLE TOILET	SINGLE TOILET	TWIN TOILET	TWIN TOILET	KITCHEN/SERVICE	KITCHEN/SERVICE	SINGLE TOILET	TWIN TOILET	SINGLE TOILET	TWIN TOILET	SINGLE TOILET

- SYMBOLS:-
- DWS(P) - DOMESTIC WATER SUPPLY PIPE (BY PRESSURISED SYSTEM)
 - DWS(G) - DOMESTIC WATER SUPPLY PIPE (BY GRAVITY)
 - MWS(G) - METRO WATER SUPPLY PIPE (BY GRAVITY)
 - TES(G) - TREATED EFFLUENT SUPPLY PIPE (BY GRAVITY)
 - NRV - NON RETURN VALVE
 - BV - BELOW 50mm - BALL VALVE, ABOVE 50mm - BUTTERFLY VALVE
 - PS - PIPE SIZE REDUCER
 - ST - STRAINER

- NOTES FOR TERRACE PIPING:
- USE uPVC SCHEDULE 80/40 AQUACOLD uPVC PIPE FOR COLD WATER AT TERRACE AND SHAFT AREAS.
 - PROVIDE SUPPORTS FOR PIPES AT EVERY 1.50M INTERVALS.
 - BALL VALVE/BUTTERFLY VALVE NEED TO BE PROVIDED IN EACH VERTICAL WATER SUPPLY DROP PIPES FROM OVERHEAD WATER TANK AT ACCESSIBLE LOCATION.

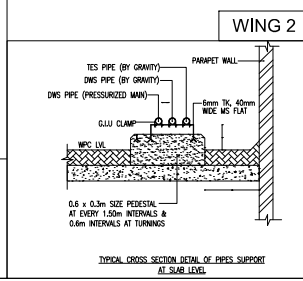

GENERAL NOTES

KEY PLAN

PART A

PART B

RO	ISSUED FOR APPROVAL	26.06.2024	SADIQUE
NO.	REVISION/ISSUE	DATE	DRAWN

PROJECT TITLE:

Proposed Residential Building
"S&P NEW HAVEN RIBBON WALK"
For M/S. S&P FOUNDATIONS,
At Mambakkam Wing 2 & 7, Chennai.

ARCHITECT:


ANBU & FAIZAL
Architects and Interior Designers
OFF-3, II FLOOR "AMAR SINDUR"
43, PANTHEON ROAD,
EGMORE, CHENNAI - 600 008
Phone - 044 - 2855 4262, 044 - 2841 0888.
E-mail - anbu.faizal@gmail.com
Web - anbuandfaizal.com

Balu & Associates
Public Health Engineers & Fire Fighting Consultants
No.10/5, Second Floor, Mahalakshmi Street,
Tambaram East, Chennai-600 059, Telfax : Ph : 044-2239 2178
E-mail : engineering@balunassociates.com &
balu_associates@yahoo.co.in
Website : www.balunassociates.com


DRAWING TITLE:

PLAN - LOCATION OF DOMESTIC WATER
& TREATED EFFLUENT TANK
AND TERRACE PIPING

PROJECT NO : 0000/000	SHEET NO:
DRAWN BY : SADIQUE	BA/S&P-NHRW/PHE/003
CHECKED BY : SARATH	NORTH POINT:
SCALE : A1 = 1:80 A3 = 1:160	North W E S
DATE : 26.06.2024	

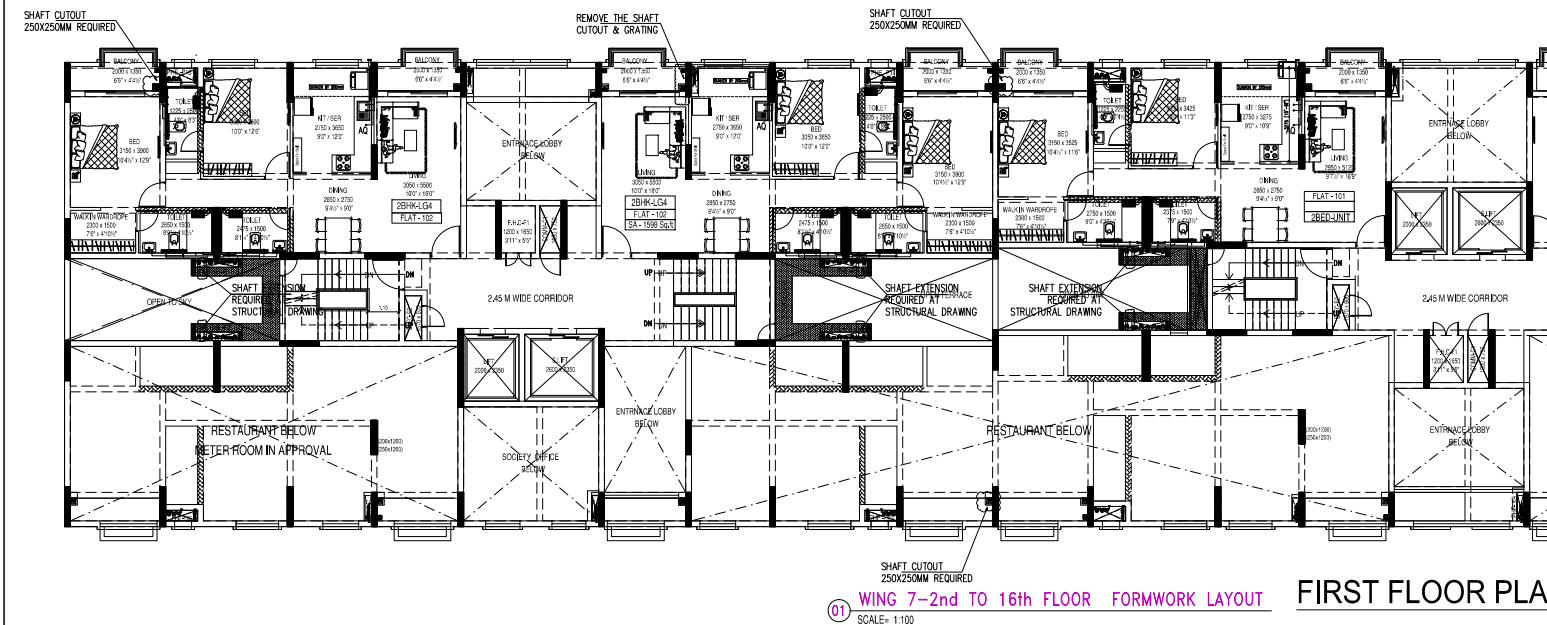


PART A

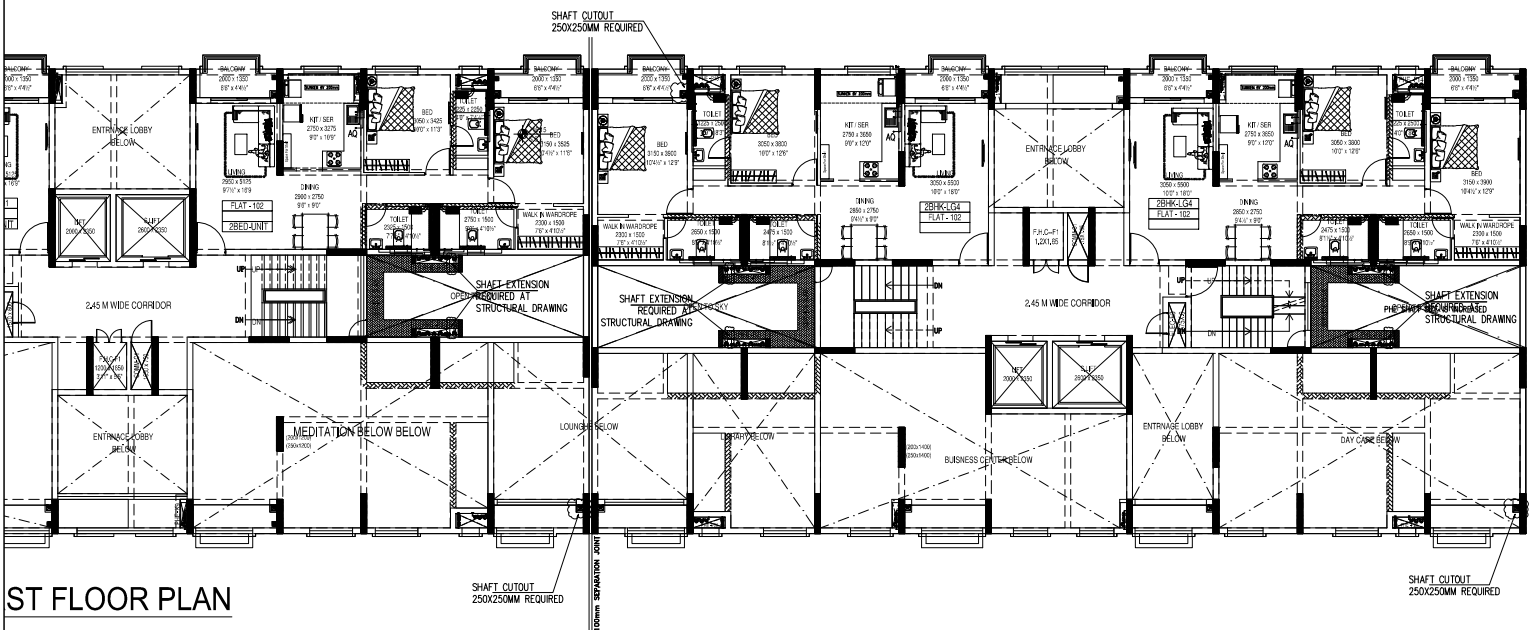

PART B

PLAN - LAYOUT OF WATER SUPPLY PIPE ARRANGEMENTS AT FIRST FLOOR PLAN

KEY PLAN

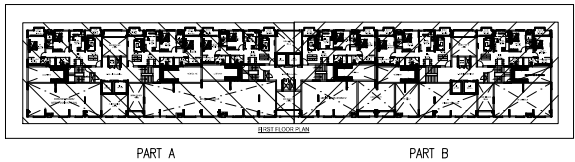

GENERAL NOTES

RO	ISSUED FOR APPROVAL	26.06.2024	SADIQUE
NO.	REVISION/ISSUE	DATE	DRAWN

PROJECT TITLE:

Proposed Residential Building
"S&P NEW HAVEN RIBBON WALK"
For M/S. S&P FOUNDATIONS,
At Mambakkam Wing 2 & 7, Chennai.

ARCHITECT:

ANBU & FAIZAL
Architects and Interior Designers
OFF-3, II FLOOR "AMAR SINDUR"
43, PANTHEON ROAD,
EGMORE, CHENNAI - 600 008
Phone - 044 - 2855 4262, 044 - 2841 0888.
E-mail -> anbu.faizal@gmail.com
Web -> anbuandfaizal.com



Balu & Associates
Public Health Engineers & Fire Fighting Consultants
No.10/5, Second Floor, Mahabakshmi Street,
Tambaram East, Chennai-600 059, Telfax : Ph : 044-2239 2178
E-mail : engineering@balunassociates.com &
balu_associates@yahoo.co.in
Website : www.balunassociates.com

DRAWING TITLE:

PLAN - LAYOUT OF WATER SUPPLY PIPE
ARRANGEMENTS AT FIRST FLOOR PLAN

PROJECT NO : 0000/000	SHEET NO: BA/S&P-NHRW/PHE/001
DRAWN BY : SADIQUE	
CHECKED BY : SARATH	NORTH POINT:
SCALE : A1 = 1:80 A3 = 1:160	North W E S
DATE : 26.06.2024	


SYMBOL	DESCRIPTION OF SYMBOL	NOTES:
	WALLHUNG EUROPEAN WATER CLOSET WITH DUAL FLUSHING CISTERN (EXPOSED TANK)	01 - USE CPVC SDR 13.5 & 11 GRADE FOR INTERNAL COLD & HOT WATER SUPPLY PIPES RESPECTIVELY. 02 - AVOID USING G.I EXTENSION NIPPLES FOR CONNECTING WITH C.P FITTINGS.
	RECTANGULAR WASHBASIN	03 - DOMESTIC WATER WILL BE USED FOR HEALTH FAUCETS, WASHBASIN, SINK, WASHING MACHINE & SHOWER.
	SINGLE BOWL SINK WITH DRAIN BOARD	04 - TREATED WATER WILL BE USED FOR FLUSHING CISTERN.
	WASHING MACHINE	05 - METRO WATER WILL BE USED FOR DRINKING & COOKING.
	SHOWER ARM & ROSE	06 - HOT WATER WILL BE USED FOR SHOWER ONLY.
	DR - DIVERTOR AT 4'-0" ABOVE FFL	07 - PROVIDE CONTROL VALVE ON ALL BRANCH RISER/DROP PIPES AT ACCESSIBLE LOCATION.
	WM - WALLMOUNTER AT 3'-0" ABOVE FFL	08 - ALL WATER SUPPLY PIPES ARE TO BE HYDRAULICALLY TESTED TO 7kg/ SQ.Cm OR 1.5 TIMES OF THE WORKING PRESSURE, WHICH EVER IS HIGHER TO MINIMUM OF 60 MINUTES.
	OVERHEAD SHOWER AT 6'-0" ABOVE FFL	09 - BEFORE PROCEEDING WITH INTERNAL WATER SUPPLY WORK, CONTRACTOR TO VERIFY THE INLET & OUTLET OF THE SELECTED SANITARY WARES & C/P.FITTINGS. NO WORK ARE TO BE CARRIED OUT WITHOUT HAVING THE SAMPLE OF ALL - TO THE TYPE OF THE SAME AT SITE.
	HWS - HOT WATER SUPPLY PIPE	10 - ALL PIPES WILL BE SUPPORTED IN WALL.
	TES - TREATED EFFLUENT SUPPLY PIPE	11 - ALL WATER SUPPLY PIPES ARE TO BE HYDRAULICALLY TESTED TO 7kg/SQ.Cm OR 1.5 TIMES OF THE WORKING PRESSURE, WHICH EVER IS HIGHER TO MINIMUM OF 60 MINUTES.
	DWS (P) - DOMESTIC WATER SUPPLY PIPE (PRESSURIZED MAIN)	
	BV - BALL VALVE	

- MATERIAL TO BE USED:
- WATER SUPPLY PIPES (INTERNAL) - CPVC SDR 13.5 FOR COLD WATER
CPVC SDR 11 FOR HOT WATER
 - WATER SUPPLY PIPES (SHAFT & TERRACE) - UPVC SCH 40 / 80
 - WATER SUPPLY PIPES (BURIED) - UPVC SCH 80


LEVELS FOR SANITARY FITTINGS:

- FC - FLUSHING CISTERN (CONCEALED)
AV/AFBC - ANGLE VALVE STOP COCK AT 1'-8" ABOVE FFL TO CONNECT HEALTH FAUCET BIBCOCK
AV/WB - ANGLE VALVE STOP COCK AT 1'-8" ABOVE FFL TO CONNECT WASH BASIN
CSC - CONCEALED STOP COCK AT 5'-6" ABOVE FFL

- ABBREVIATIONS:-
- HFBC - HEALTH FAUCET BIBCOCK
 - FC - FLUSHING CISTERN
 - WB - WASHBASIN
 - WM - WASHING MACHINE
 - SH - SHOWER
 - CSC - CONCEALED STOPCOCK
 - AG - AQUAGUARD

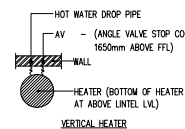


WING 7

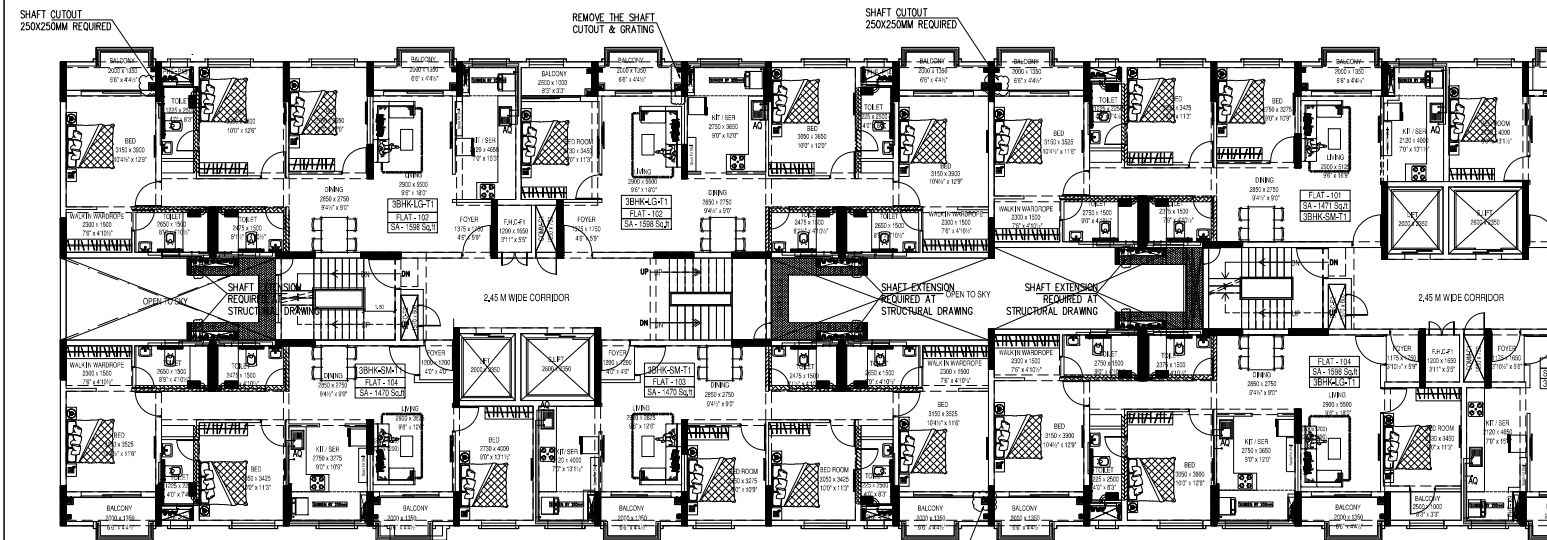

WING 7-2nd TO 16th FLOOR FORMWORK LAYOUT
SCALE= 1:100
TYPICAL FLOOR PLAN
[2nd, 7th, 8th, 9th, 10th, 15th & 16th F

PART A

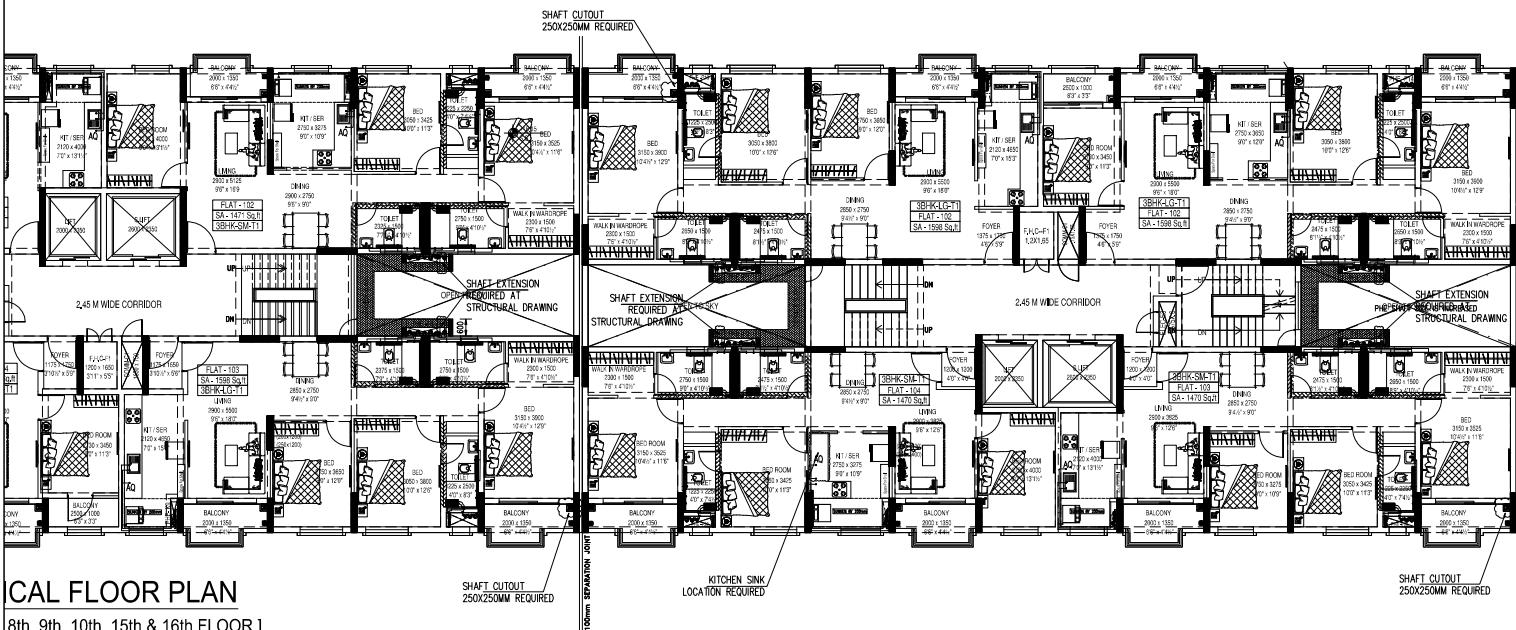


TYPICAL FLOOR PLAN
[8th, 9th, 10th, 15th & 16th FLOOR]

PART B

PLAN - LAYOUT OF WATER SUPPLY PIPE ARRANGEMENTS AT TYPICAL FLOOR PLAN 2nd,7th,8th,9th,10th,15th & 16th FLOOR

KEY PLAN

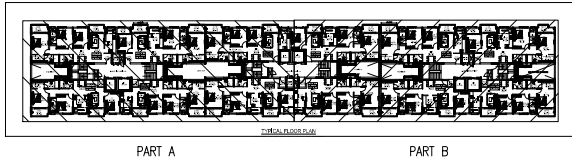

GENERAL NOTES

RO	ISSUED FOR APPROVAL	26.06.2024	SADIQUE
NO.	REVISION/ISSUE	DATE	DRAWN

PROJECT TITLE:

Proposed Residential Building
"S&P NEW HAVEN RIBBON WALK"
For M/S. S&P FOUNDATIONS,
At Mambakkam Wing 2 & 7, Chennai.

ARCHITECT:

ANBU & FAIZAL
Architects and Interior Designers
OFF-3, II FLOOR "AMAR SINDUR"
43, PANTHEON ROAD,
EGMORE, CHENNAI - 600 008
Phone - 044 - 2855 4262, 044 - 2841 0888.
E-mail - anbu.faizal@gmail.com
Web - anbuandfaizal.com



Balu & Associates
Public Health Engineers & Fire Fighting Consultants
No.10/5, Second Floor, Mahabikshmi Street,
Tambaram East, Chennai-600 059, Tel:044 - 2239 2178
E:mail - engineering@balunassociates.com &
balu_associates@yahoo.co.in
Website : www.balunassociates.com

DRAWING TITLE:


PLAN - LAYOUT OF WATER SUPPLY PIPE
ARRANGEMENTS AT TYPICAL FLOOR PLAN
2nd,7th,8th,9th,10th,15th & 16th FLOOR

PROJECT NO : 0000/000	SHEET NO: BA/S&P-NHRW/PHE/002
DRAWN BY : SADIQUE	NORTH POINT: North W E S
CHECKED BY : SARATH	SCALE : A1 = 1:80 A3 = 1:160
DATE : 26.06.2024	

SYMBOL	DESCRIPTION OF SYMBOL	NOTES:
	WALLHUNG EUROPEAN WATER CLOSET WITH DUAL FLUSHING CISTERN (EXPOSED TANK)	01 - USE CPVC SDR 13.5 & 11 GRADE FOR INTERNAL COLD & HOT WATER SUPPLY PIPES RESPECTIVELY.
	RECTANGULAR WASHBASIN	02 - AVOID USING G.I EXTENSION NIPPLES FOR CONNECTING WITH C.P FITTINGS.
	SINGLE BOWL SINK WITH DRAIN BOARD	03 - DOMESTIC WATER WILL BE USED FOR HEALTH FAUCETS, WASHBASIN, SINK, WASHING MACHINE & SHOWER.
	WASHING MACHINE	04 - TREATED WATER WILL BE USED FOR FLUSHING CISTERN.
	SHOWER ARM & ROSE	05 - METRO WATER WILL BE USED FOR DRINKING & COOKING.
	DR - DIVERTOR AT 4'-0" ABOVE FFL	06 - HOT WATER WILL BE USED FOR SHOWER ONLY.
	WM - WALLMOUNT SHOWER AT 3'-0" ABOVE FFL	07 - PROVIDE CONTROL VALVE ON ALL BRANCH RISER/DROP PIPES AT ACCESSIBLE LOCATION.
	OS - OVERHEAD SHOWER AT 6'-0" ABOVE FFL	08 - ALL WATER SUPPLY PIPES ARE TO BE HYDRAULICALLY TESTED TO 7kg/ SQ.Cm OR 1.5 TIMES OF THE WORKING PRESSURE, WHICH EVER IS HIGHER TO MINIMUM OF 60 MINUTES.
	HWS - HOT WATER SUPPLY PIPE	09 - BEFORE PROCEEDING WITH INTERNAL WATER SUPPLY WORK, CONTRACTOR TO VERIFY THE INLET & OUTLET OF THE SELECTED SANITARY WARE & C.P.FITTINGS. NO WORK ARE TO BE CARRIED OUT WITHOUT HAVING THE SAMPLE OF ALL - TO THE TYPE OF THE SAME AT SITE.
	TES - TREATED EFFLUENT SUPPLY PIPE	10 - ALL PIPES WILL BE SUPPORTED IN WALL.
	DWS (P) - DOMESTIC WATER SUPPLY PIPE (PRESSURIZED MAIN)	11 - ALL WATER SUPPLY PIPES ARE TO BE HYDRAULICALLY TESTED TO 7kg/5Q.Cm OR 1.5 TIMES OF THE WORKING PRESSURE, WHICH EVER IS HIGHER TO MINIMUM OF 60 MINUTES.
	Dx BY - BALL VALVE	

MATERIAL TO BE USED:	ABBREVIATIONS:
● WATER SUPPLY PIPES (INTERNAL) - CPVC SDR 13.5 FOR COLD WATER	HFBC - HEALTH FAUCET BIBCOCK
● WATER SUPPLY PIPES (SHAFT &) - CPVC SDR 11 FOR HOT WATER	FC - FLUSHING CISTERN
(TERRACE)	WB - WASHBASIN
● WATER SUPPLY PIPES (BURIED) - UPVC SCH 80	WM - WASHING MACHINE
	SH - SHOWER
	CSC - CONCEALED STOPCOCK
	AG - AQUAGUARD

LEVELS FOR SANITARY FITTINGS:
FC - FLUSHING CISTERN (CONCEALED)
AV/HFBC - ANGLE VALVE STOP COCK AT 1'-6" ABOVE FFL TO CONNECT HEALTH FAUCET BIBCOCK
AV/WM - ANGLE VALVE STOP COCK AT 1'-6" ABOVE FFL TO CONNECT WASH BASIN
CSC - CONCEALED STOP COCK AT 5'-6" ABOVE FFL

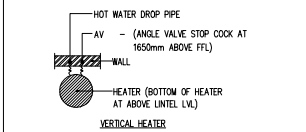


WING 7



PART A

PART B

PLAN - LOCATION OF DOMESTIC WATER & TREATED EFFLUENT TANK & TERRACE PIPING

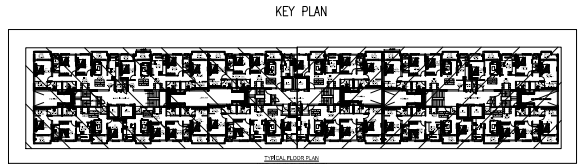

PART A


PART B

SYMBOLS:-

- DWS(P) - DOMESTIC WATER SUPPLY PIPE (BY PRESSURISED SYSTEM)
DWS(G) - DOMESTIC WATER SUPPLY PIPE (BY GRAVITY)
MWS(G) - METRO WATER SUPPLY PIPE (BY GRAVITY)
TES(G) - TREATED EFFLUENT SUPPLY PIPE (BY GRAVITY)
NRV - NON RETURN VALVE
BV - BELOW 50mm - BALL VALVE
ABOVE 50mm - BUTTERFLY VALVE
PSR - PIPE SIZE REDUCER
ST - STRAINER

NOTES FOR TERRACE PIPING:

- USE UPVC SCHEDULE 80/40 AQUAGOLD UPVC PIPE FOR COLD WATER AT TERRACE AND SHAFT AREAS.
- PROVIDE SUPPORTS FOR PIPES AT EVERY 1.50m INTERVALS.
- BALL VALVE/BUTTERFLY VALVE NEED TO BE PROVIDED IN EACH VERTICAL WATER SUPPLY DROP PIPES FROM OVERHEAD WATER TANK AT ACCESSIBLE LOCATION.

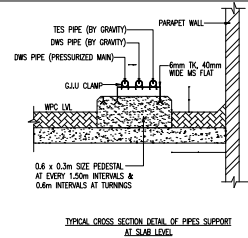

TYPICAL CROSS SECTION DETAIL OF PIPES SUPPORT AT SLAB EDGE

GENERAL NOTES

RO	ISSUED FOR APPROVAL	26.06.2024	SADIQUE
NO.	REVISION/ISSUE	DATE	DRAWN

PROJECT TITLE:

Proposed Residential Building
"S&P NEW HAVEN RIBBON WALK"
For M/S. S&P FOUNDATIONS,
At Mambakkam Wing 2 & 7, Chennai.

ARCHITECT:

ANBU & FAIZAL
Architects and Interior Designers
OFF-3, II FLOOR "AMAR SINDUR"
43, PANTHEON ROAD,
EGMORE, CHENNAI - 600 008
Phone - 044 - 2855 4262, 044 - 2841 0888.
E-mail -> anbu.faizal@gmail.com
Web -> anbuandfaizal.com

DRAWING TITLE:

PLAN - LOCATION OF DOMESTIC WATER
& TREATED EFFLUENT TANK
AND TERRACE PIPING

PROJECT NO : 0000/000	SHEET NO: BA/S&P-NHRW/PHE/004
DRAWN BY : SADIQUE	NORTH POINT:
CHECKED BY : SARATH	SCALE : A1 = 1:80 A3 = 1:160
DATE : 26.06.2024	North W E S

DETAILS OF WATER SUPPLY DROP PIPES															
FLOORS	DOMESTIC WATER SUPPLY PIPE (PRESSURISED MAIN & GRAVITY) & TREATED EFFLUENT WATER SUPPLY PIPE (BY GRAVITY)														
TENTH FLOOR	MWS(G) TES(G) DWS(G) DWS(P) TES(G) DWS(G) DWS(P) TES(G) DWS(G) DWS(P) TES(G) DWS(G) DWS(P)														
NINTH FLOOR	MWS(G) TES(G) DWS(G) DWS(P) TES(G) DWS(G) DWS(P) TES(G) DWS(G) DWS(P) TES(G) DWS(G) DWS(P)														
EIGHTH FLOOR	MWS(G) TES(G) DWS(G) DWS(P) TES(G) DWS(G) DWS(P) TES(G) DWS(G) DWS(P) TES(G) DWS(G) DWS(P)														
SEVENTH FLOOR	MWS(G) TES(G) DWS(G) DWS(P) TES(G) DWS(G) DWS(P) TES(G) DWS(G) DWS(P) TES(G) DWS(G) DWS(P)														
SIXTH FLOOR	MWS(G) TES(G) DWS(G) DWS(P) TES(G) DWS(G) DWS(P) TES(G) DWS(G) DWS(P) TES(G) DWS(G) DWS(P)														
FIFTH FLOOR	MWS(G) TES(G) DWS(G) DWS(P) TES(G) DWS(G) DWS(P) TES(G) DWS(G) DWS(P) TES(G) DWS(G) DWS(P)														
FOURTH FLOOR	MWS(G) TES(G) DWS(G) DWS(P) TES(G) DWS(G) DWS(P) TES(G) DWS(G) DWS(P) TES(G) DWS(G) DWS(P)														
THIRTEENTH FLOOR	MWS(G) TES(G) DWS(G) DWS(P) TES(G) DWS(G) DWS(P) TES(G) DWS(G) DWS(P) TES(G) DWS(G) DWS(P)														
TWELTH FLOOR	MWS(G) TES(G) DWS(G) DWS(P) TES(G) DWS(G) DWS(P) TES(G) DWS(G) DWS(P) TES(G) DWS(G) DWS(P)														
ELEVENTH FLOOR	MWS(G) TES(G) DWS(G) DWS(P) TES(G) DWS(G) DWS(P) TES(G) DWS(G) DWS(P) TES(G) DWS(G) DWS(P)														
TENTH FLOOR	MWS(G) TES(G) DWS(G) DWS(P) TES(G) DWS(G) DWS(P) TES(G) DWS(G) DWS(P) TES(G) DWS(G) DWS(P)														
NINTH FLOOR	MWS(G) TES(G) DWS(G) DWS(P) TES(G) DWS(G) DWS(P) TES(G) DWS(G) DWS(P) TES(G) DWS(G) DWS(P)														
DROP PIPES		① DROP	② DROP	③ DROP	④ DROP	⑤ DROP	⑥ DROP	⑦ DROP	⑧ DROP	⑨ DROP	⑩ DROP	⑪ DROP	⑫ DROP	⑬ DROP	⑭ DROP
		SINGLE TOILET	SINGLE TOILET	TWIN TOILET	TWIN TOILET	KITCHEN/SERVICE	KITCHEN/SERVICE	SINGLE TOILET	TWIN TOILET	SINGLE TOILET	TWIN TOILET	SINGLE TOILET	TWIN TOILET	SINGLE TOILET	TWIN TOILET

WING 7

Our services go beyond



Buying & Selling Services

Property Buying Assistance, Property Selling Support, Market Price Analysis, Owner Outreach and Negotiation.



Legal & Documentation Services

Certified EC, Patta, legal opinions, property verification, due diligence, litigation solutions, and legal heir certificates.



Property Development & Approvals

Building plan approvals, construction, layout and sub-division approvals, zone conversion, and occupancy certification.



NRI & Investment Services

Escrow Services, Rentals, Litigation Solutions, Property Valuation and Property Management



Compliance & Special Services

Demolition, Vaasthu checks, regularization of unauthorized buildings, and office space solutions.

Smarter Tools, Stronger Decisions



Property Valuation & Cost Estimation

Guideline Value, Apartment Composite Value, Stamp Duty & Registration Fees Calculator, Building Value Calculator, Capital Gains Calculator, Area Unit Converter, Length Unit Converter



Ownership, Compliance & Legal Verification

Encumbrance Certificate (EC) Search, Find Your SRO, Temple Property Check, WAQF Property Check, View Patta/Chitta, View FMB, Patta Analyzer, EC Analyzer



Zoning & Land Use Analysis

Land Use Zone Finder, CRZ Zone Check, Aquifer Zone Check, CBA Check, EWS Check, Road Width Check, Proposed Road Widening Check, FSI Calculator



Property Documentation & Workflow Tools

Forms & Templates, Document Generator, Document Translation, Dictionary



Vastu & Property Management Tools

Home Vastu Shastra, Plot Vastu Shastra, Property Management

Verified RealEstateTM

We're honored to be part of your
real estate journey

3/350/2 Mettukuppam,
OMR Thoraipakkam,
Chennai, India

hello@verified.realestate
+91 9996 12 9996
www.verified.realestate